



MASTER PLAN OF THQ HOSPITAL SOHAWA

PART 1

PART 2

PART 3

PART 4

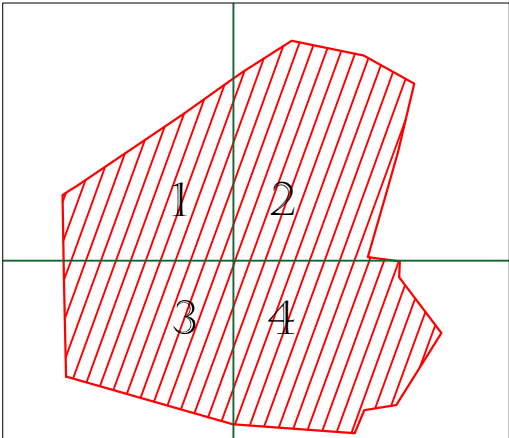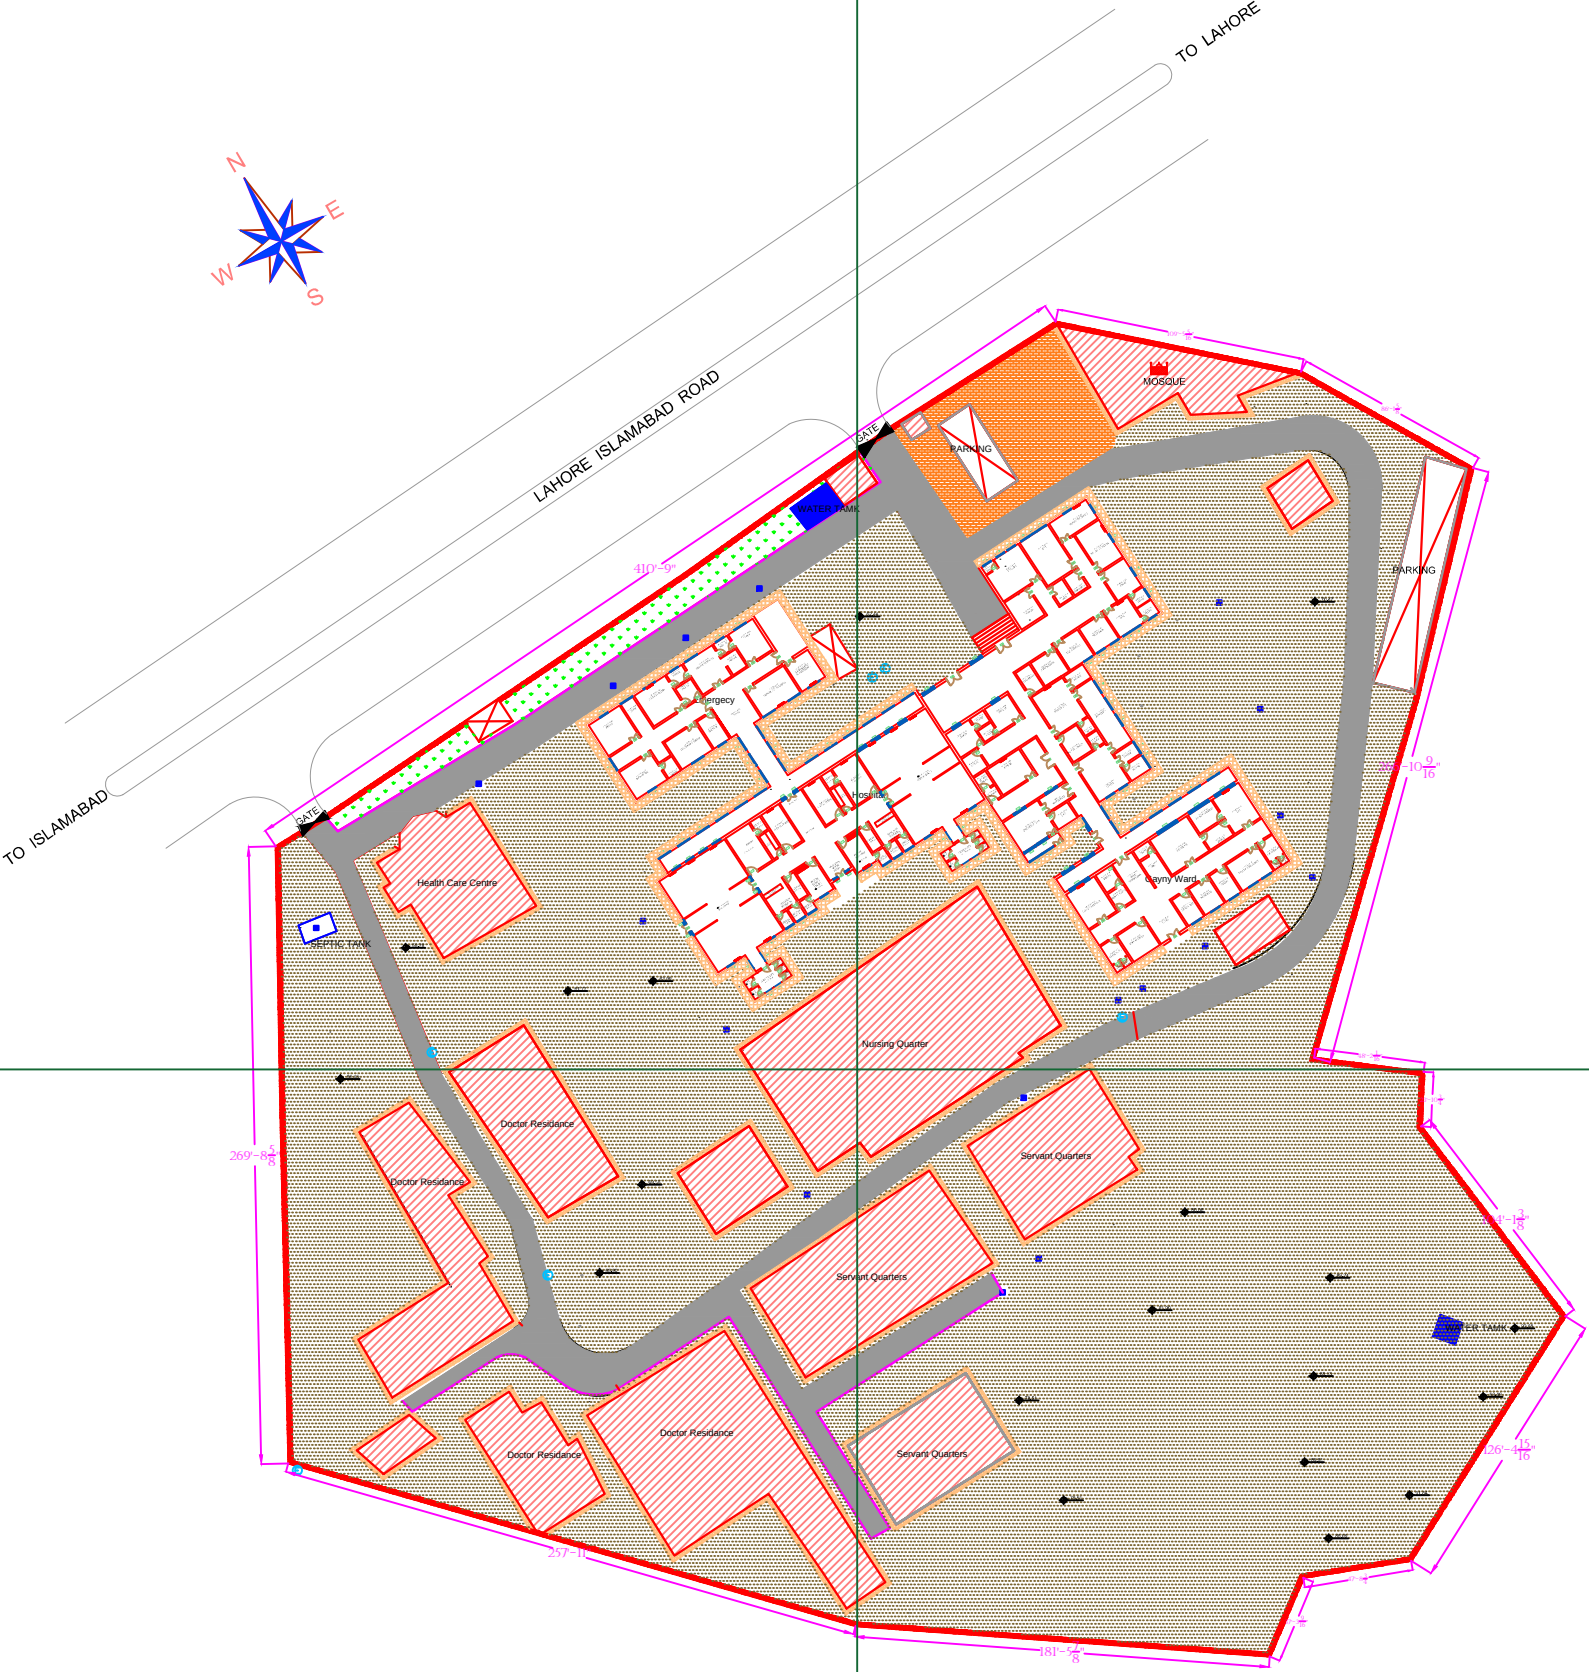

Legends:

Residential Area	
Road	
Wall	
Power Line	
OHT	
Tree	
Man Hole	
Tube Well	
Light Pole	
Lawns	
Earthen Areas	
Asphalts Roads	
Tough Pavers	
P.C.C / Plinth Protection	
Boundary Wall	
Brick Pavers / Soling	
Drain	
Tap	
Hand Pump	
Air Conditioner	
Tube Light	
Fan	
Roof Light	
Bulb	

AREA	
AREA WITHIN BOUNDARY WALL	236175.48 SFT
AREA OF CLINICAL BLOCK	26582.258 SFT
PLINTH AREA OF BLOCK	26582.258 SFT

OPENING SCHEDULE OF DOORS AND WINDOWS					
DOORS	WIDTH	HEIGHT	WINDOWS	WIDTH	HEIGHT
D1	5'-6"	7'-0"	W1	3'-0"	3'-0"
D2	5'-0"	7'-0"	W2	3'-6"	3'-6"
D3	4'-0"	7'-0"	W3	6'-0"	6'-0"
D4	3'-6"	7'-0"	W4	4'-6"	4'-6"
D5	3'-0"	7'-0"	W5	8'-6"	8'-6"
D6	2'-6"	7'-0"	W6	2'-6"	2'-6"
D7	6'-0"	7'-0"	W7	4'-0"	4'-0"
V1	1'-6"	1'-6"	W8	5'-0"	5'-0"
V2	2'-0"	2'-0"	W9	7'-0"	7'-0"

Project:
**CAD MAPPING OF TEHSIL
HEAD QUARTER HOSPITALS,
PUNJAB**




Client: GOVERNMENT OF THE PUNJAB PRIMARY & SECONDARY HEALTHCARE DEPARTMENT	Consultant: SKAFS CONSULTANT (Pvt.) Limited ENGINEERING AND ENVIRONMENT CONSULTANT
---	--

Drawing Title:
**THQ SOHAWA
HOSPITAL MASTER PLAN**

Drawing No.
SKAFS/SOHAWA /03

MASTER PLAN OF THQ HOSPITAL SOHAWA

PART 1

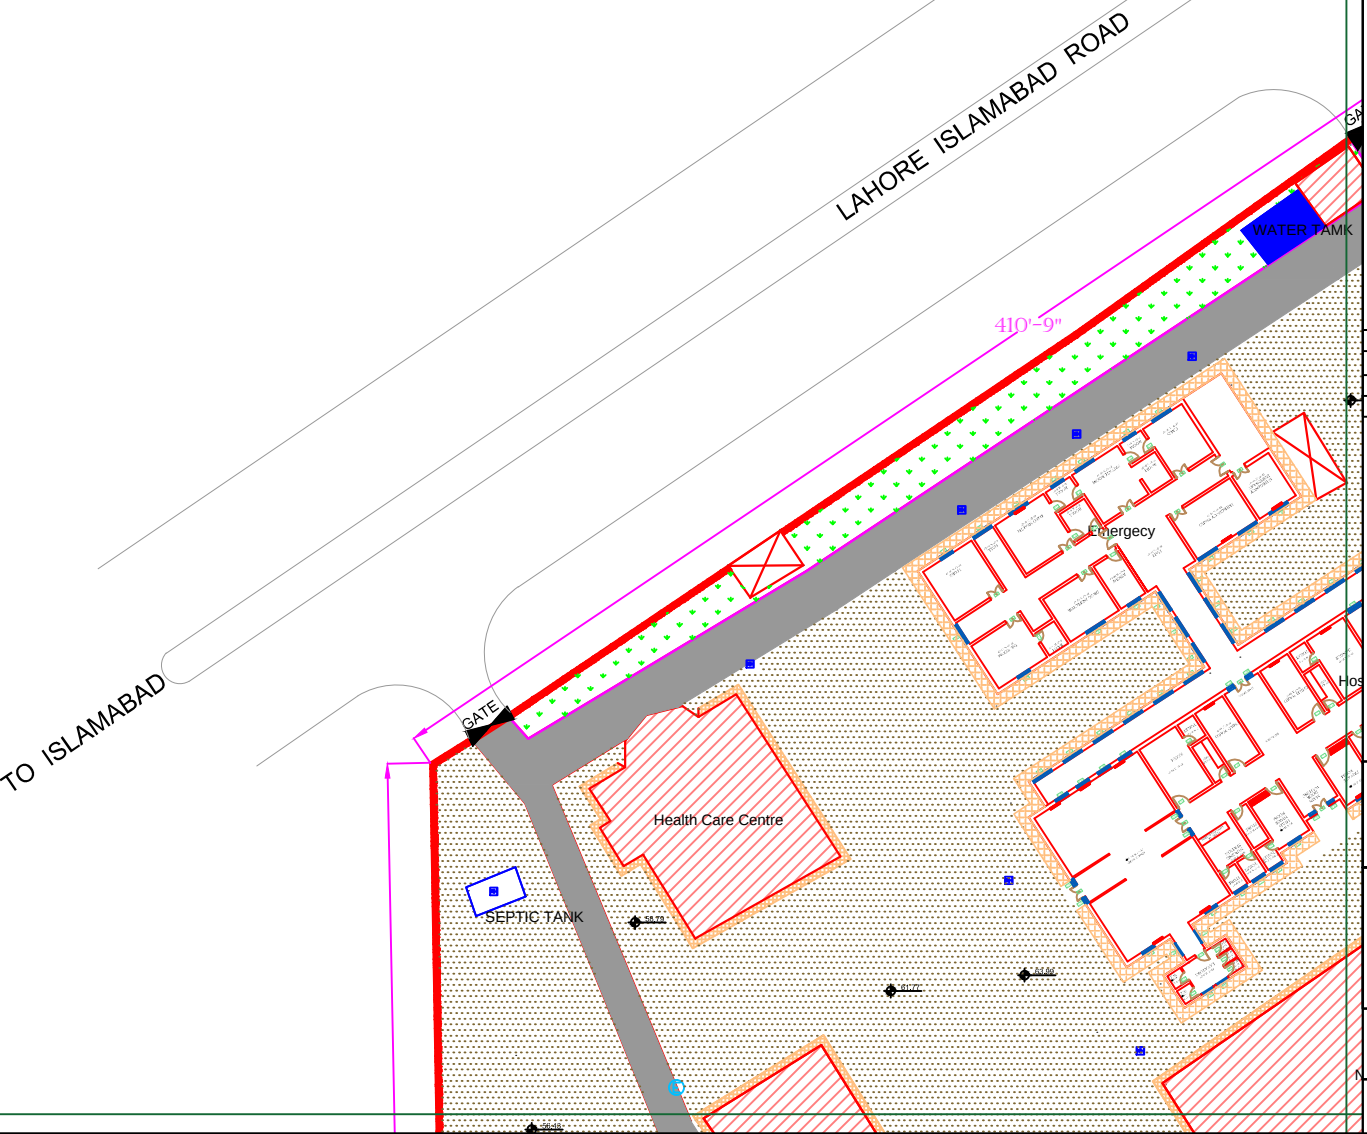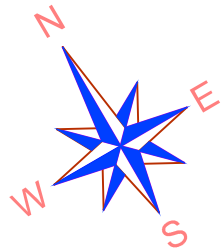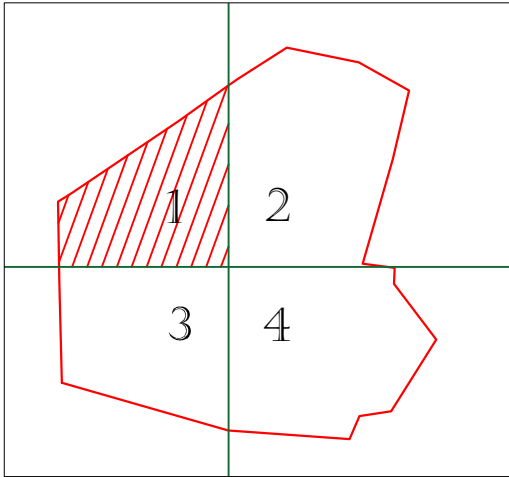

Legends:	
Residential Area	
Road	
Wall	
Power Line	
OHT	
Tree	
Man Hole	
Tube Well	
Light Pole	
Lawns	
Earthen Areas	
Asphalts Roads	
Tough Pavers	
P.C.C / Plinth Protection	
Boundary Wall	
Brick Pavers / Soling	
Drain	
Tap	
Hand Pump	
Air Conditioner	
Tube Light	
Fan	
Roof Light	
Bulb	

AREA	
AREA WITHIN BOUNDARY WALL	236175.48 SFT
AREA OF CLINICAL BLOCK	26582.258 SFT
PLINTH AREA OF BLOCK	26582.258 SFT

OPENING SCHEDULE OF DOORS AND WINDOWS					
DOORS	WIDTH	HEIGHT	WINDOWS	WIDTH	HEIGHT
D1	5'-6"	7'-0"	W1	3'-0"	3'-0"
D2	5'-0"	7'-0"	W2	3'-6"	3'-6"
D3	4'-0"	7'-0"	W3	6'-0"	6'-0"
D4	3'-6"	7'-0"	W4	4'-6"	4'-6"
D5	3'-0"	7'-0"	W5	8'-6"	8'-6"
D6	2'-6"	7'-0"	W6	2'-6"	2'-6"
D7	6'-0"	7'-0"	W7	4'-0"	4'-0"
V1	1'-6"	1'-6"	W8	5'-0"	5'-0"
V2	2'-0"	2'-0"	W9	7'-0"	7'-0"



Project:
**CAD MAPPING OF TEHSIL
HEAD QUARTER HOSPITALS,
PUNJAB**

Client: GOVERNMENT OF THE PUNJAB PRIMARY & SECONDARY HEALTHCARE DEPARTMENT	Consultant: SKAFS CONSULTANT (Pvt.) Limited ENGINEERING AND ENVIRONMENT CONSULTANT
---	--

Drawing Title:
**THQ SOHAWA
HOSPITAL MASTER PLAN PART 1**

Drawing No.
SKAFS/SOHAWA /04

MASTER PLAN OF THQ HOSPITAL SOHAWA
PART 2

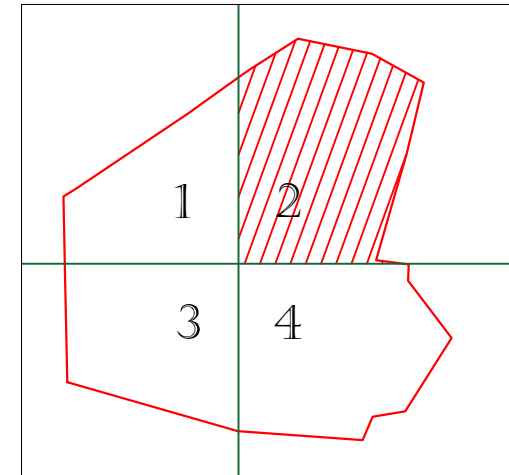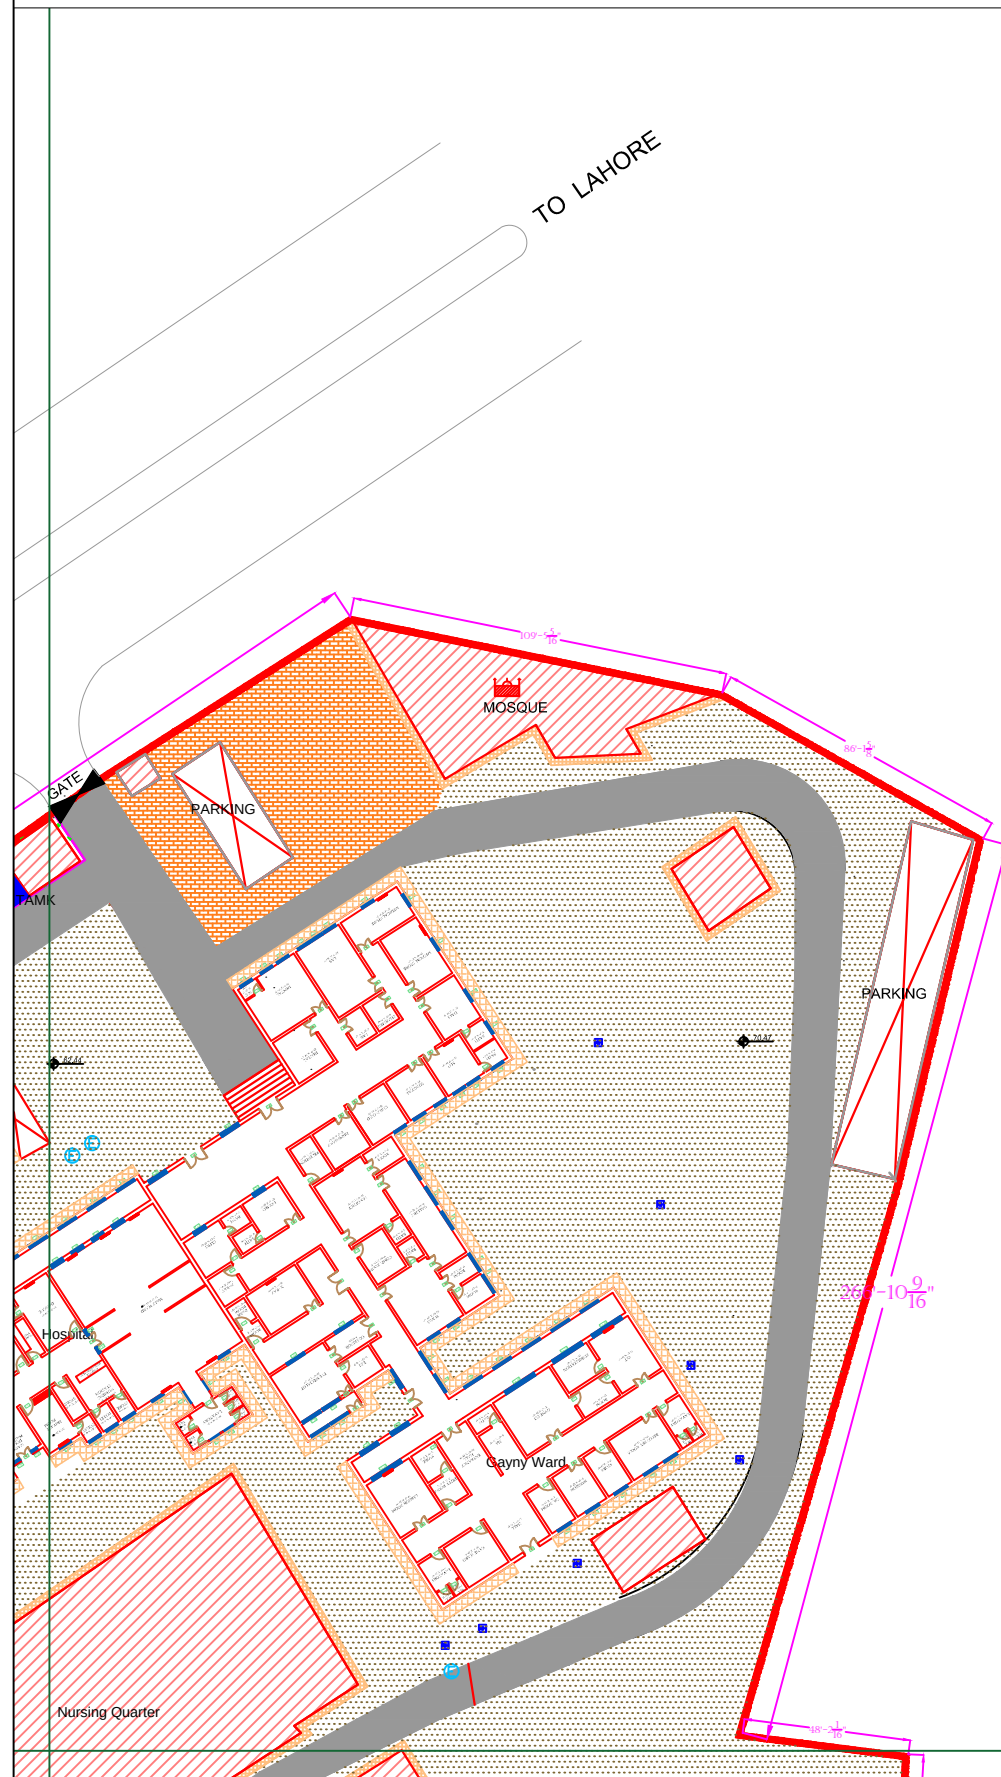

Legends:	
Residential Area	
Road	
Wall	
Power Line	
OHT	
Tree	
Man Hole	
Tube Well	
Light Pole	
Lawns	
Earthen Areas	
Asphalts Roads	
Tough Pavers	
P.C.C / Plinth Protection	
Boundary Wall	
Brick Pavers / Soling	
Drain	
Tap	
Hand Pump	
Air Conditioner	
Tube Light	
Fan	
Roof Light	
Bulb	

AREA	
AREA WITHIN BOUNDARY WALL	236175.48 SFT
AREA OF CLINICAL BLOCK	26582.258 SFT
PLINTH AREA OF BLOCK	26582.258 SFT

OPENING SCHEDULE OF DOORS AND WINDOWS					
DOORS	WIDTH	HEIGHT	WINDOWS	WIDTH	HEIGHT
D1	5'-6"	7'-0"	W1	3'-0"	3'-0"
D2	5'-0"	7'-0"	W2	3'-6"	3'-6"
D3	4'-0"	7'-0"	W3	6'-0"	6'-0"
D4	3'-6"	7'-0"	W4	4'-6"	4'-6"
D5	3'-0"	7'-0"	W5	8'-6"	8'-6"
D6	2'-6"	7'-0"	W6	2'-6"	2'-6"
D7	6'-0"	7'-0"	W7	4'-0"	4'-0"
V1	1'-6"	1'-6"	W8	5'-0"	5'-0"
V2	2'-0"	2'-0"	W9	7'-0"	7'-0"

Project:
**CAD MAPPING OF TEHSIL
HEAD QUARTER HOSPITALS,
PUNJAB**



Client:  GOVERNMENT OF THE PUNJAB PRIMARY & SECONDARY HEALTHCARE DEPARTMENT	Consultant:  SKAFS CONSULTANT (Pvt.) Limited <i>ENGINEERING AND ENVIRONMENT CONSULTANT</i>
--	---

Drawing Title:	THQ SOHAWA HOSPITAL MASTER PLAN PART 2
----------------	---

Drawing No. **SKAFS/SOHAWA /05**

MASTER PLAN OF THQ HOSPITAL SOHAWA

PART 3

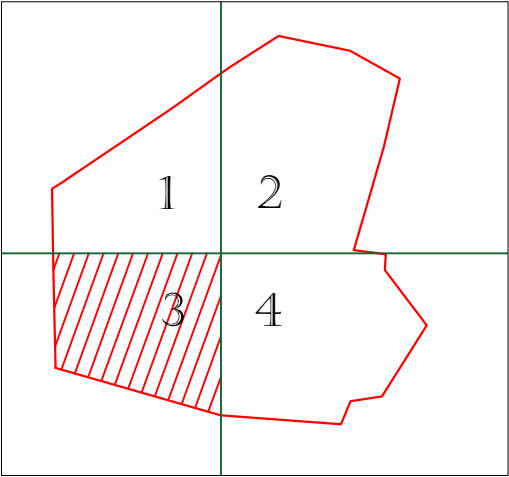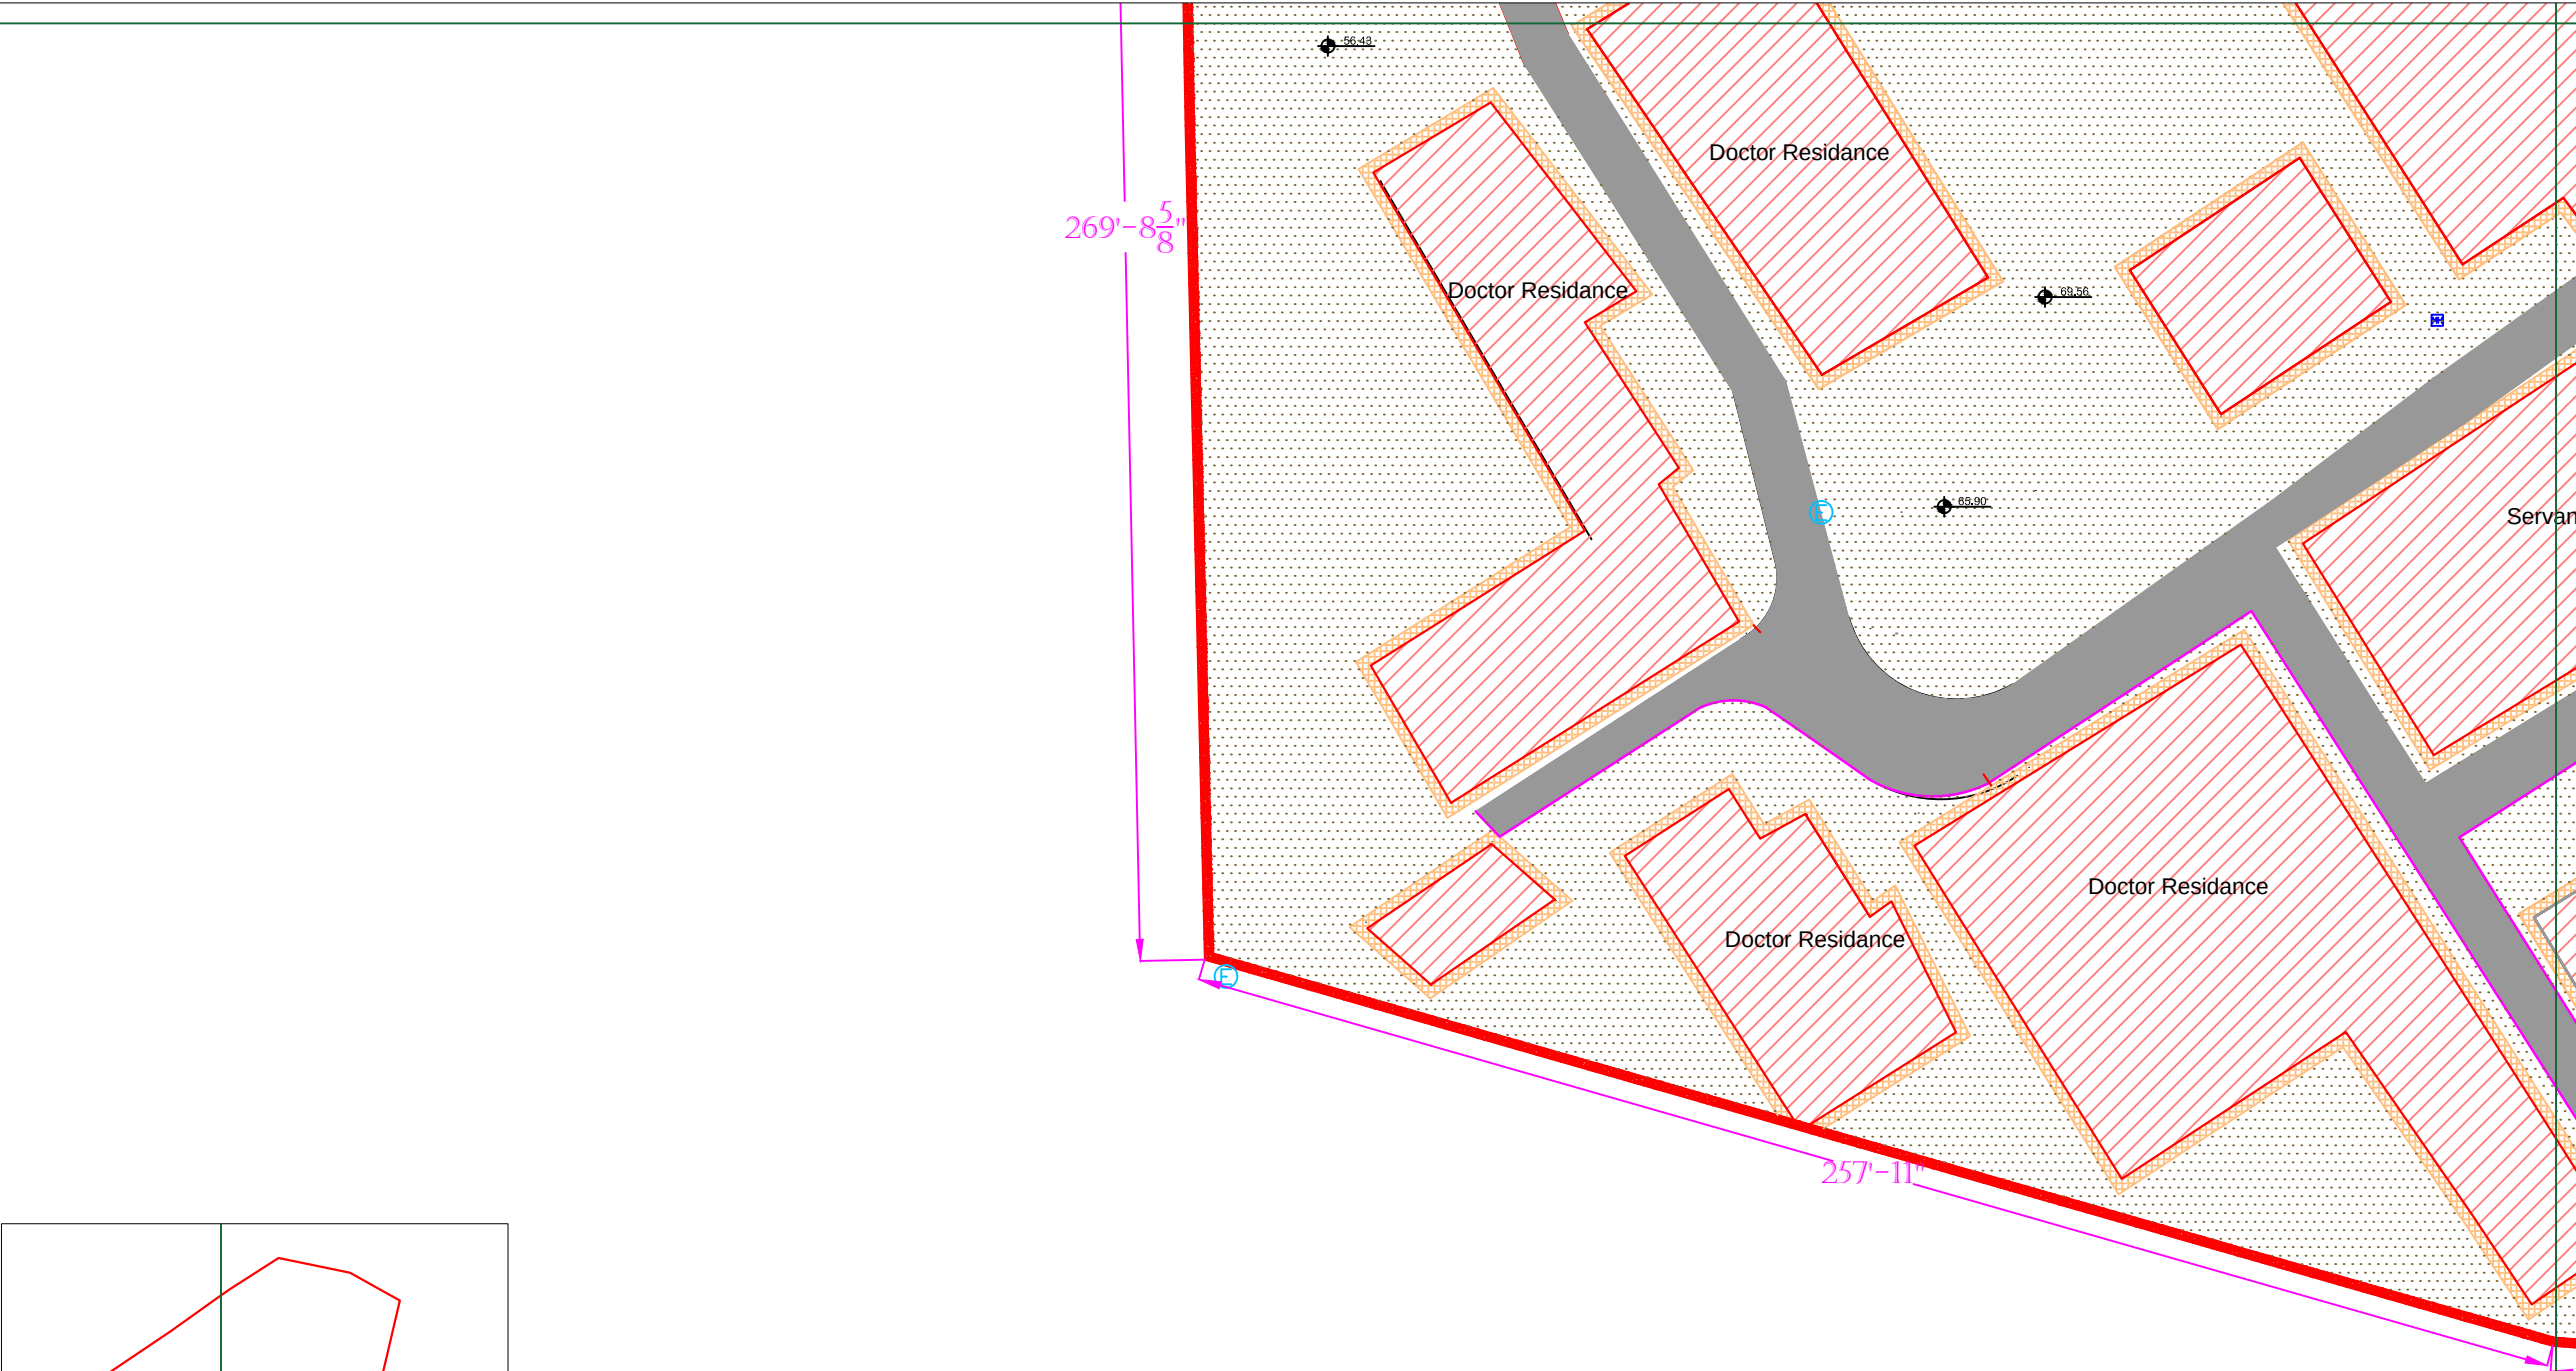

Legends:	
Residential Area	
Road	
Wall	
Power Line	
OHT	
Tree	
Man Hole	
Tube Well	
Light Pole	
Lawns	
Earthen Areas	
Asphalts Roads	
Tough Pavers	
P.C.C / Plinth Protection	
Boundary Wall	
Brick Pavers / Soling	
Drain	
Tap	
Hand Pump	
Air Conditioner	
Tube Light	
Fan	
Roof Light	
Bulb	


AREA	
AREA WITHIN BOUNDARY WALL	236175.48 SFT
AREA OF CLINICAL BLOCK	26582.258 SFT
PLINTH AREA OF BLOCK	26582.258 SFT

OPENING SCHEDULE OF DOORS AND WINDOWS					
DOORS	WIDTH	HEIGHT	WINDOWS	WIDTH	HEIGHT
D1	5'-6"	7'-0"	W1	3'-0"	3'-0"
D2	5'-0"	7'-0"	W2	3'-6"	3'-6"
D3	4'-0"	7'-0"	W3	6'-0"	6'-0"
D4	3'-6"	7'-0"	W4	4'-6"	4'-6"
D5	3'-0"	7'-0"	W5	8'-6"	8'-6"
D6	2'-6"	7'-0"	W6	2'-6"	2'-6"
D7	6'-0"	7'-0"	W7	4'-0"	4'-0"
V1	1'-6"	1'-6"	W8	5'-0"	5'-0"
V2	2'-0"	2'-0"	W9	7'-0"	7'-0"

Project: CAD MAPPING OF TEHSIL HEAD QUARTER HOSPITALS, PUNJAB	
Client: GOVERNMENT OF THE PUNJAB PRIMARY & SECONDARY HEALTHCARE DEPARTMENT	Consultant: SKAFS CONSULTANT (Pvt.) Limited ENGINEERING AND ENVIRONMENT CONSULTANT
Drawing Title: THQ SOHAWA HOSPITAL MASTER PLAN PART 3	
Drawing No. SKAFS/SOHAWA /06	

MASTER PLAN OF THQ HOSPITAL SOHAWA

PART 4

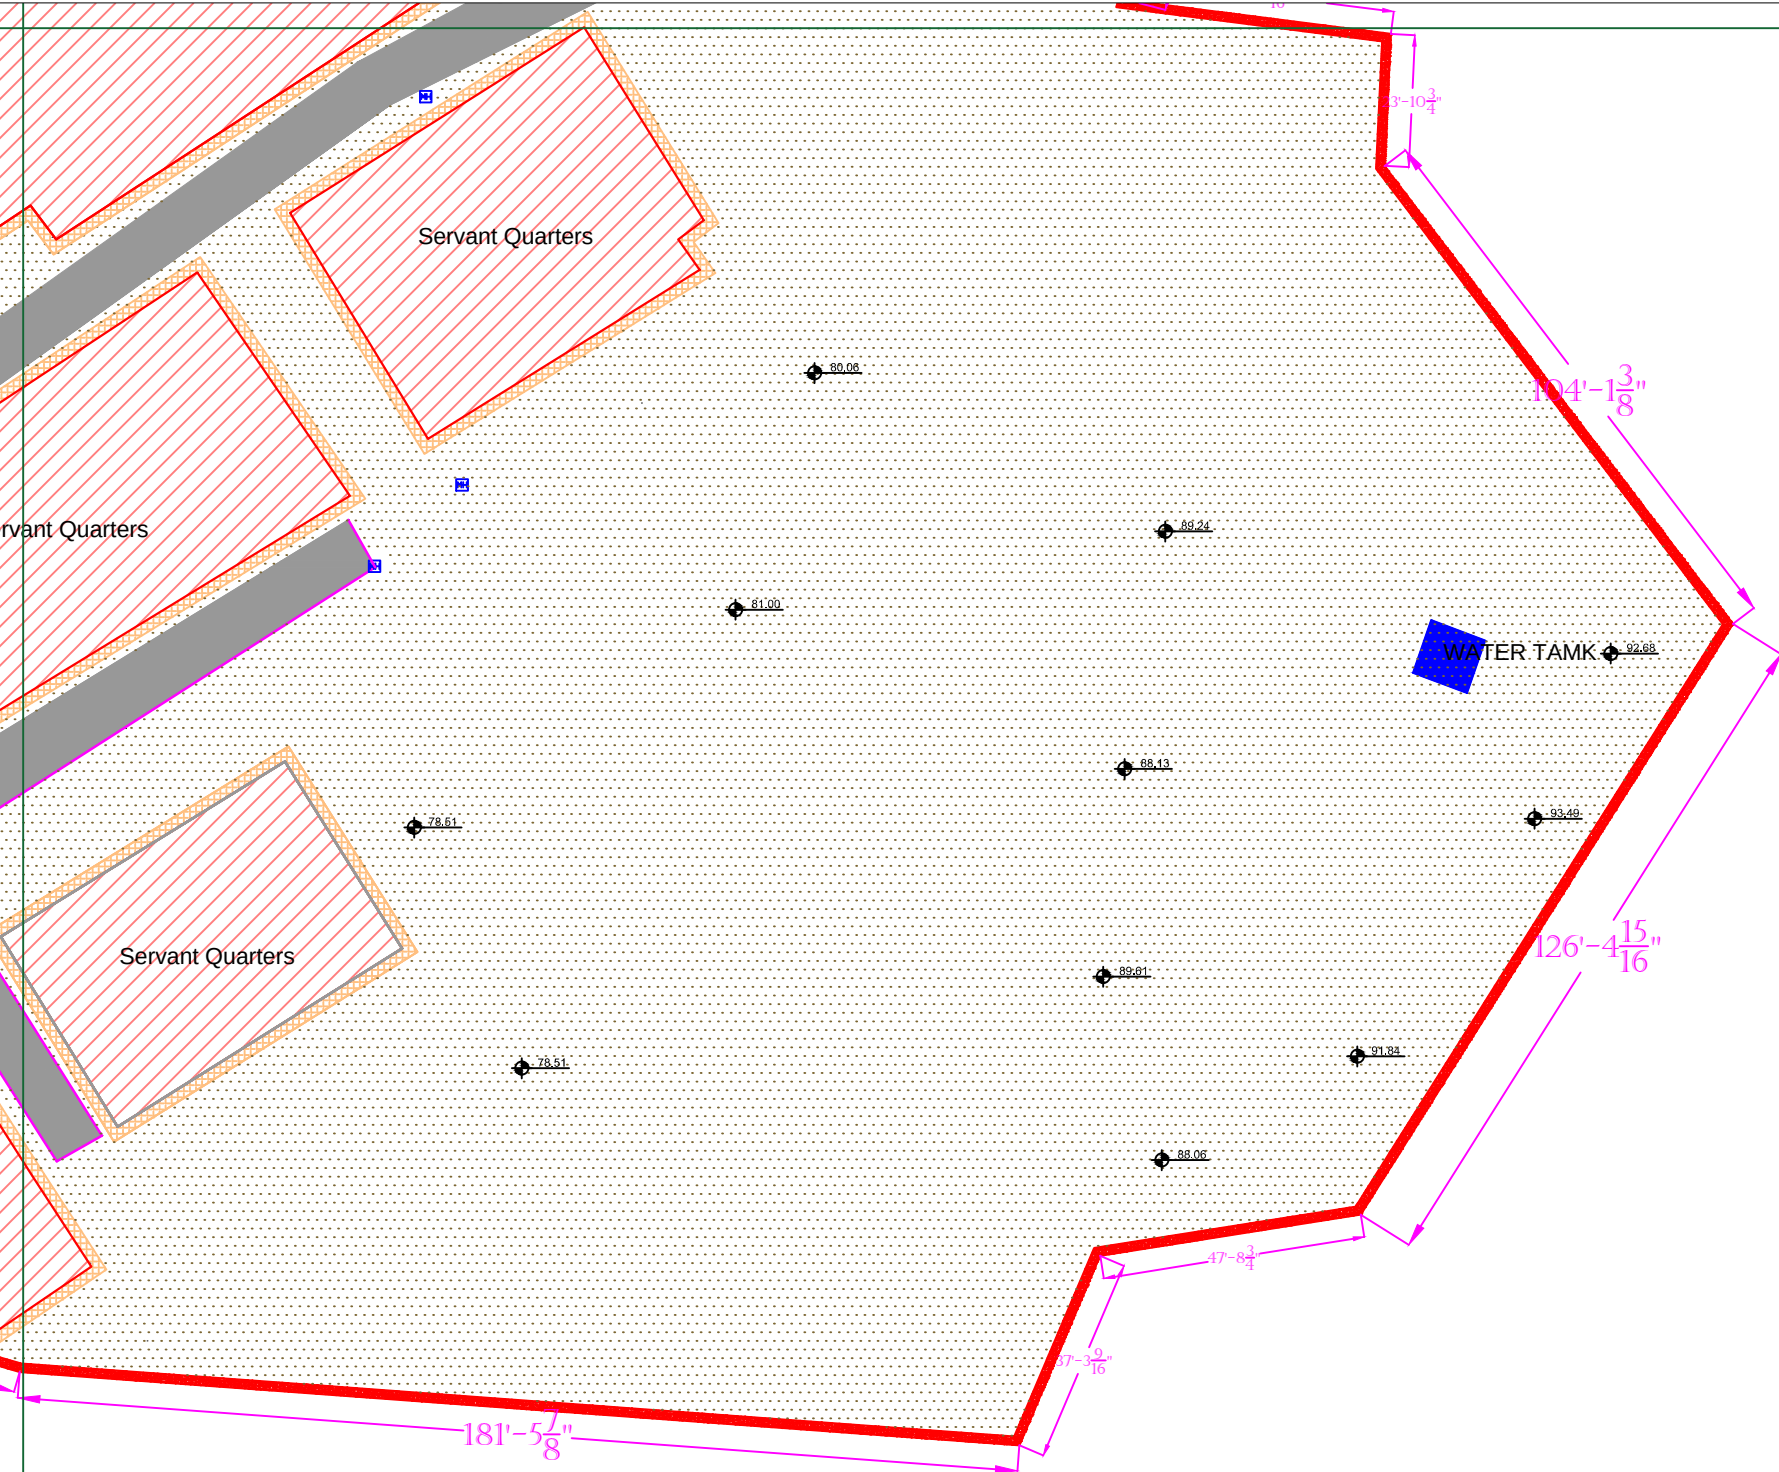

Legends:	
Residential Area	
Road	
Wall	
Power Line	
OHT	
Tree	
Man Hole	
Tube Well	
Light Pole	
Lawns	
Earthen Areas	
Asphalts Roads	
Tough Pavers	
P.C.C / Plinth Protection	
Boundary Wall	
Brick Pavers / Soling	
Drain	
Tap	
Hand Pump	
Air Conditioner	
Tube Light	
Fan	
Roof Light	
Bulb	

AREA	
AREA WITHIN BOUNDARY WALL	236175.48 SFT
AREA OF CLINICAL BLOCK	26582.258 SFT
PLINTH AREA OF BLOCK	26582.258 SFT


OPENING SCHEDULE OF DOORS AND WINDOWS					
DOORS	WIDTH	HEIGHT	WINDOWS	WIDTH	HEIGHT
D1	5'-6"	7'-0"	W1	3'-0"	3'-0"
D2	5'-0"	7'-0"	W2	3'-6"	3'-6"
D3	4'-0"	7'-0"	W3	6'-0"	6'-0"
D4	3'-6"	7'-0"	W4	4'-6"	4'-6"
D5	3'-0"	7'-0"	W5	8'-6"	8'-6"
D6	2'-6"	7'-0"	W6	2'-6"	2'-6"
D7	6'-0"	7'-0"	W7	4'-0"	4'-0"
V1	1'-6"	1'-6"	W8	5'-0"	5'-0"
V2	2'-0"	2'-0"	W9	7'-0"	7'-0"

Project:
**CAD MAPPING OF TEHSIL
HEAD QUARTER HOSPITALS,
PUNJAB**

Client: GOVERNMENT OF THE PUNJAB PRIMARY & SECONDARY HEALTHCARE DEPARTMENT	Consultant: SKAFS CONSULTANT (Pvt.) Limited ENGINEERING AND ENVIRONMENT CONSULTANT
---	--


Drawing Title: **THQ SOHAWA
HOSPITAL MASTER PLAN PART 4**

Drawing No. **SKAFS/SOHAWA /07**

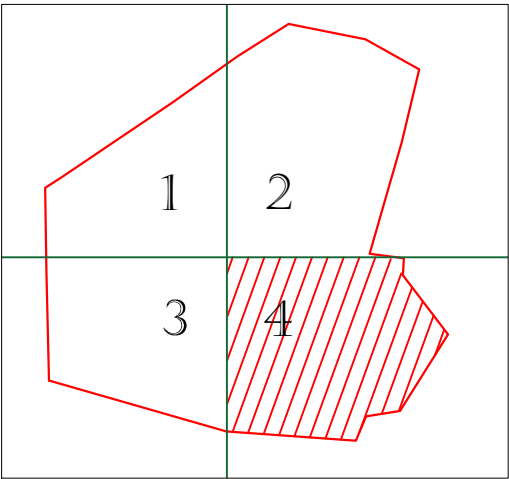

CLINICAL BLOCK OF THQ HOSPITAL SOHAWA

GROUND FLOOR

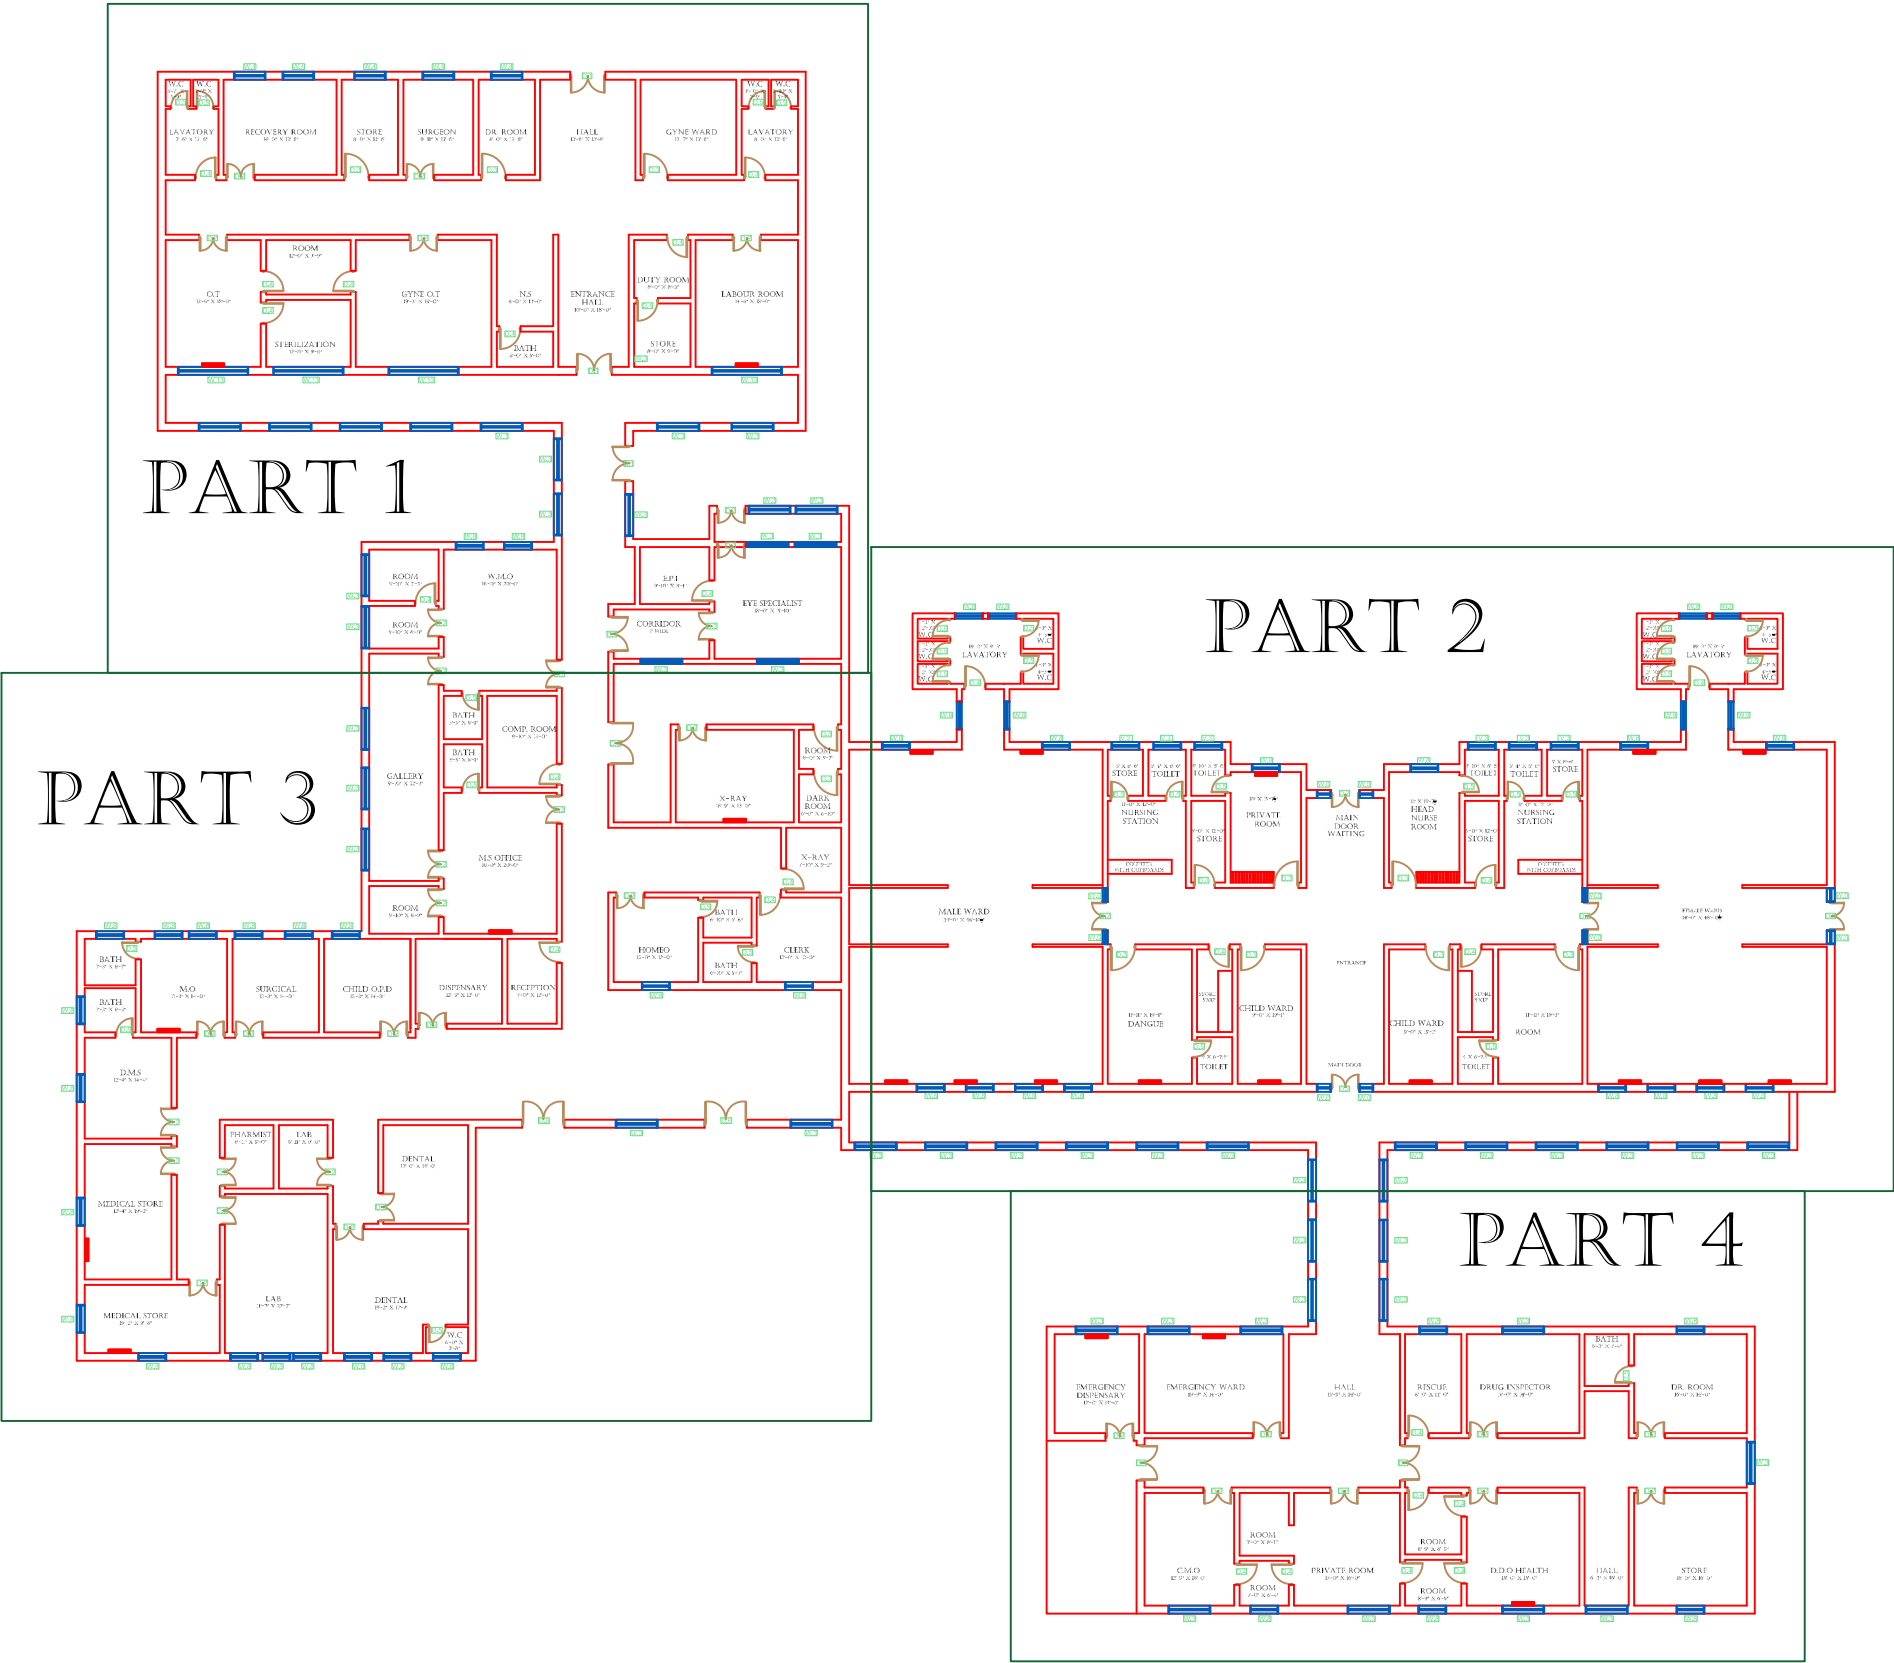

Legends:

Residential Area	
Road	
Wall	
Power Line	
OHT	
Tree	
Man Hole	
Tube Well	
Light Pole	
Lawns	
Earthen Areas	
Asphalts Roads	
Tough Pavers	
P.C.C / Plinth Protection	
Boundary Wall	
Brick Pavers / Soling	
Drain	
Tap	
Hand Pump	
Air Conditioner	
Tube Light	
Fan	
Roof Light	
Bulb	

AREA					
AREA WITHIN BOUNDARY WALL		236175.48 SFT			
AREA OF CLINICAL BLOCK		26582.258 SFT			
PLINTH AREA OF BLOCK		26582.258 SFT			

OPENING SCHEDULE OF DOORS AND WINDOWS					
DOORS	WIDTH	HEIGHT	WINDOWS	WIDTH	HEIGHT
D1	5'-6"	7'-0"	W1	3'-0"	3'-0"
D2	5'-0"	7'-0"	W2	3'-6"	3'-6"
D3	4'-0"	7'-0"	W3	6'-0"	6'-0"
D4	3'-6"	7'-0"	W4	4'-6"	4'-6"
D5	3'-0"	7'-0"	W5	8'-6"	8'-6"
D6	2'-6"	7'-0"	W6	2'-6"	2'-6"
D7	6'-0"	7'-0"	W7	4'-0"	4'-0"
V1	1'-6"	1'-6"	W8	5'-0"	5'-0"
V2	2'-0"	2'-0"	W9	7'-0"	7'-0"

Project:
**CAD MAPPING OF TEHSIL
HEAD QUARTER HOSPITALS,
PUNJAB**


Client: GOVERNMENT OF THE PUNJAB PRIMARY & SECONDARY HEALTHCARE DEPARTMENT	Consultant: SKAFS CONSULTANT (Pvt.) Limited ENGINEERING AND ENVIRONMENT CONSULTANT
---	--

Drawing Title: **THQ SOHAWA
HOSPITAL CLINICAL BLOCK PLAN**

Drawing No. **SKAFS/SOHAWA /08**

CLINICAL BLOCK OF THQ HOSPITAL SOHAWA

GROUND FLOOR PART 1

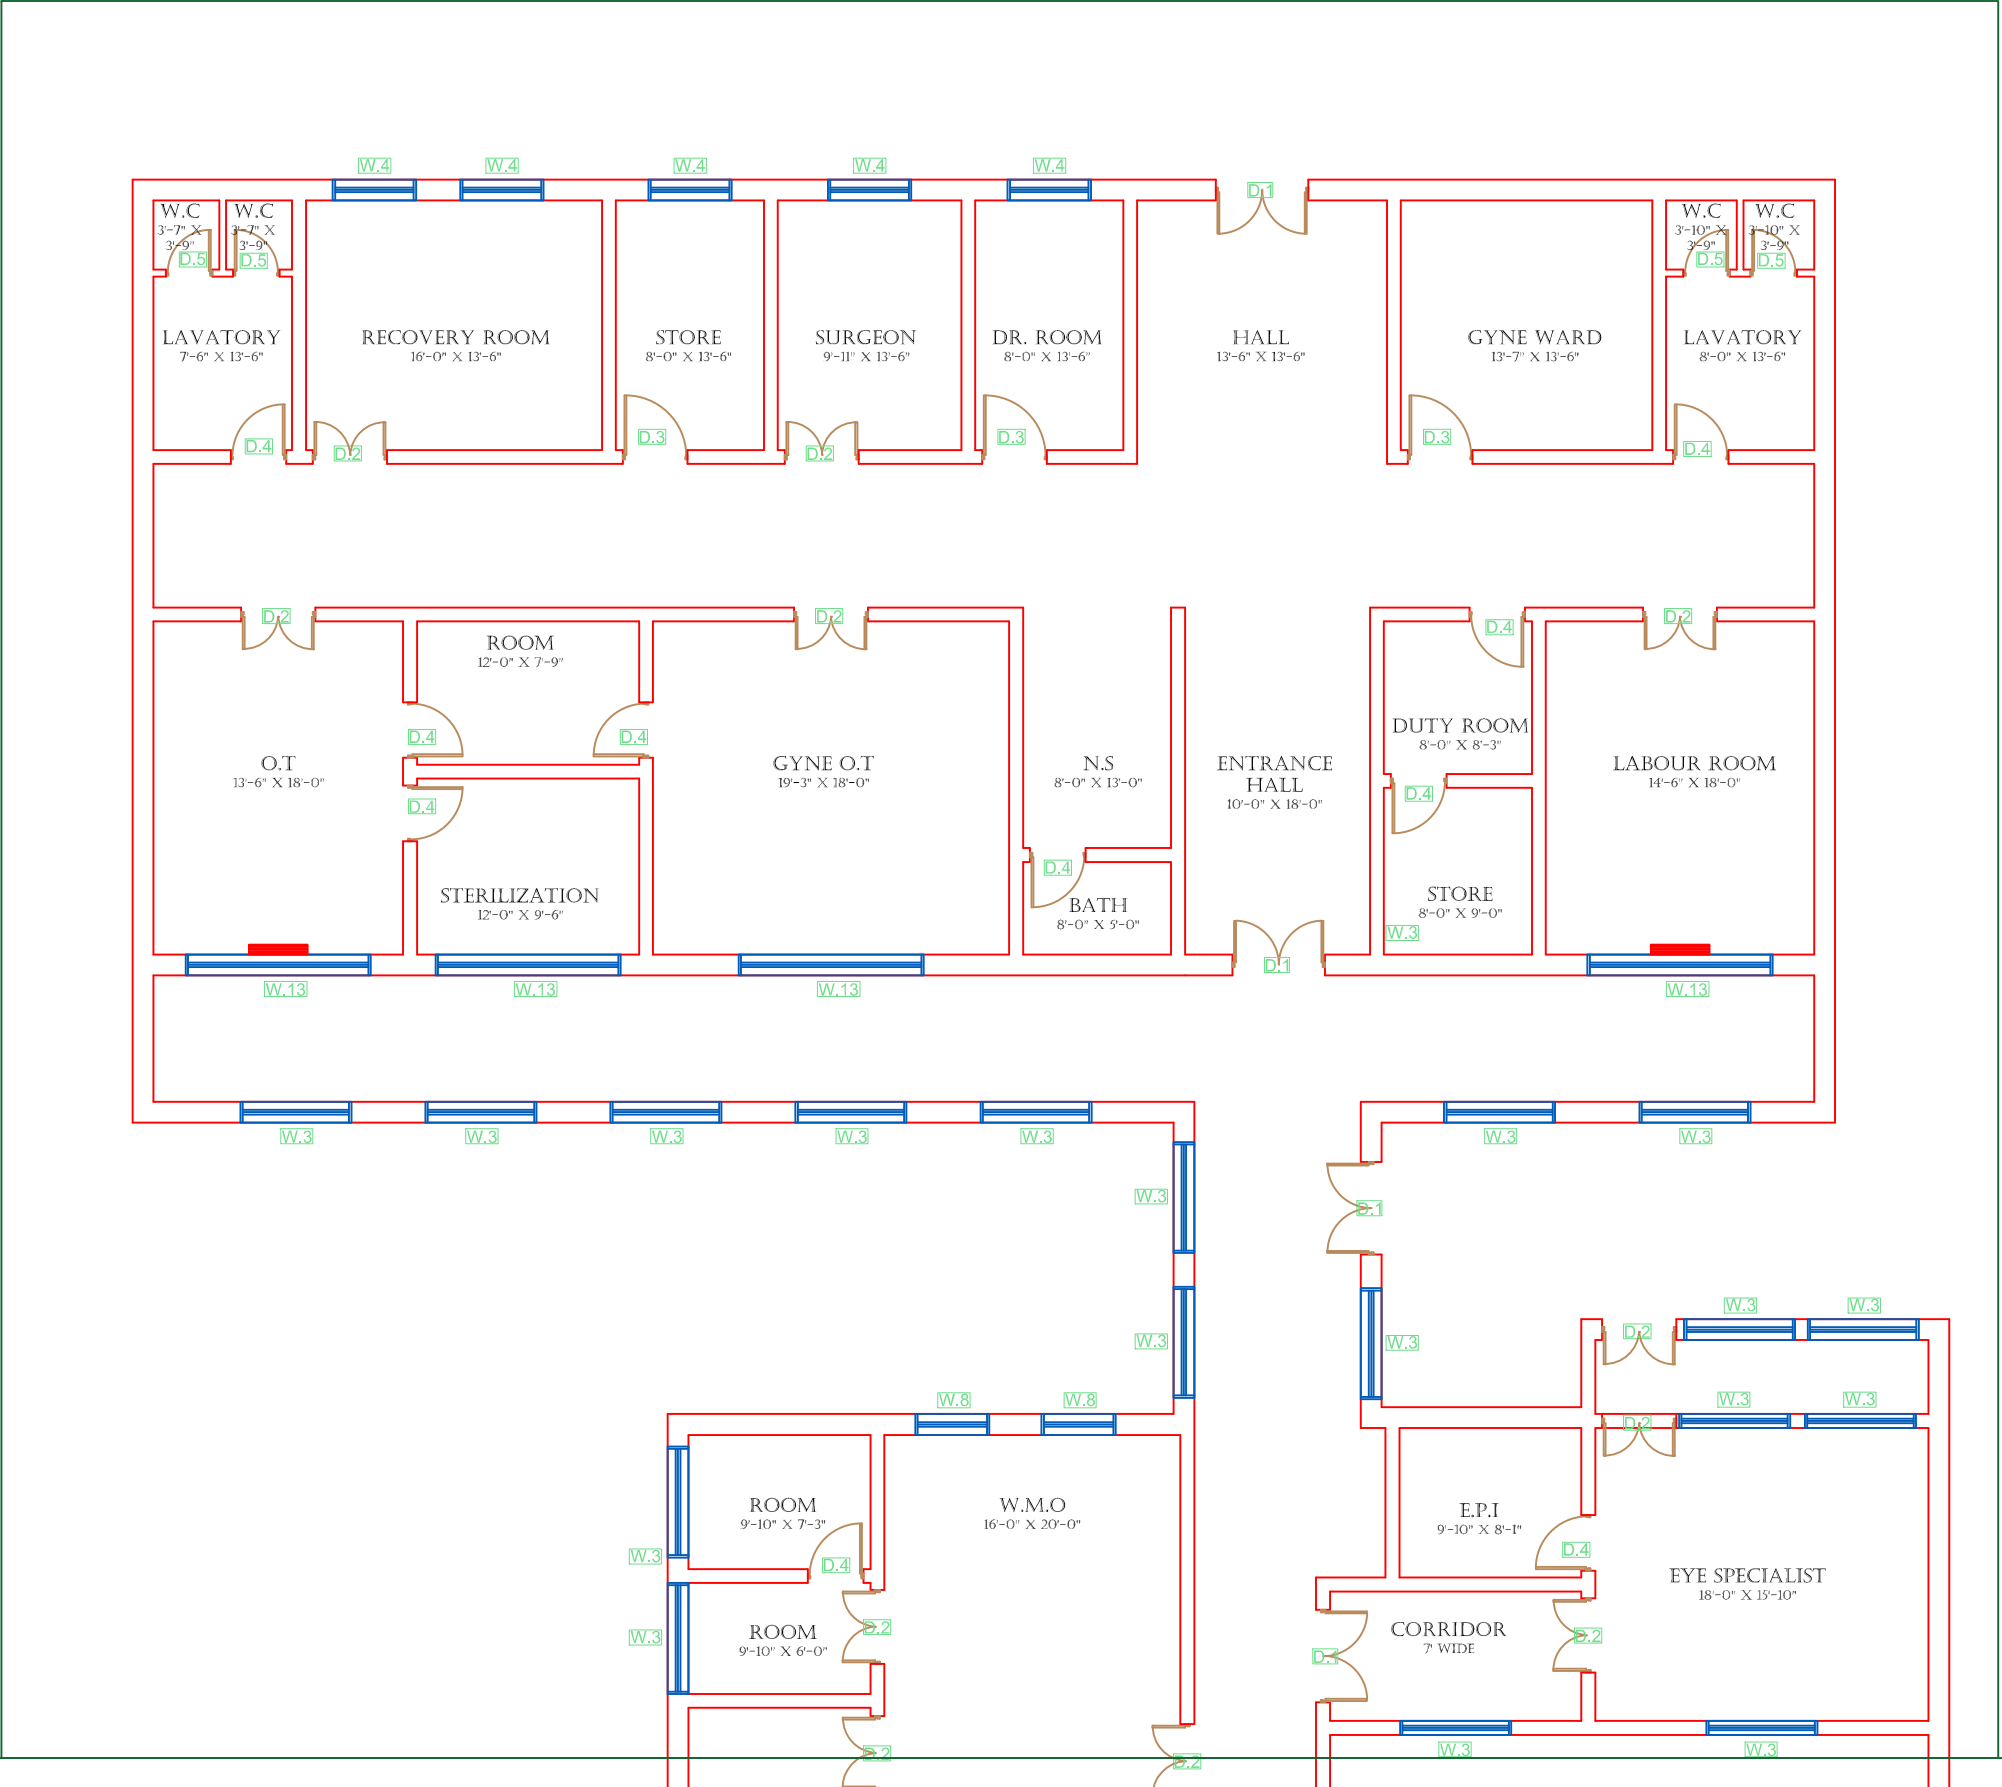

Legends:

Residential Area	
Road	
Wall	
Power Line	
OHT	
Tree	
Man Hole	
Tube Well	
Light Pole	
Lawns	
Earthen Areas	
Asphalts Roads	
Tough Pavers	
P.C.C / Plinth Protection	
Boundary Wall	
Brick Pavers / Soling	
Drain	
Tap	
Hand Pump	
Air Conditioner	
Tube Light	
Fan	
Roof Light	
Bulb	

AREA

AREA WITHIN BOUNDARY WALL	236175.48 SFT
AREA OF CLINICAL BLOCK	26582.258 SFT
PLINTH AREA OF BLOCK	26582.258 SFT

OPENING SCHEDULE OF DOORS AND WINDOWS

DOORS	WIDTH	HEIGHT	WINDOWS	WIDTH	HEIGHT
D1	5'-6"	7'-0"	W1	3'-0"	3'-0"
D2	5'-0"	7'-0"	W2	3'-6"	3'-6"
D3	4'-0"	7'-0"	W3	6'-0"	6'-0"
D4	3'-6"	7'-0"	W4	4'-6"	4'-6"
D5	3'-0"	7'-0"	W5	8'-6"	8'-6"
D6	2'-6"	7'-0"	W6	2'-6"	2'-6"
D7	6'-0"	7'-0"	W7	4'-0"	4'-0"
V1	1'-6"	1'-6"	W8	5'-0"	5'-0"
V2	2'-0"	2'-0"	W9	7'-0"	7'-0"

Project:
**CAD MAPPING OF TEHSIL
HEAD QUARTER HOSPITALS,
PUNJAB**


Client: GOVERNMENT OF THE PUNJAB PRIMARY & SECONDARY HEALTHCARE DEPARTMENT	Consultant: SKAFS CONSULTANT (Pvt.) Limited ENGINEERING AND ENVIRONMENT CONSULTANT
---	--

Drawing Title:
**THQ SOHAWA
CLINICAL BLOCK PLAN (PART 1)**

Drawing No.
SKAFS/SOHAWA /09

CLINICAL BLOCK OF THQ HOSPITAL SOHAWA

GROUND FLOOR PART 2

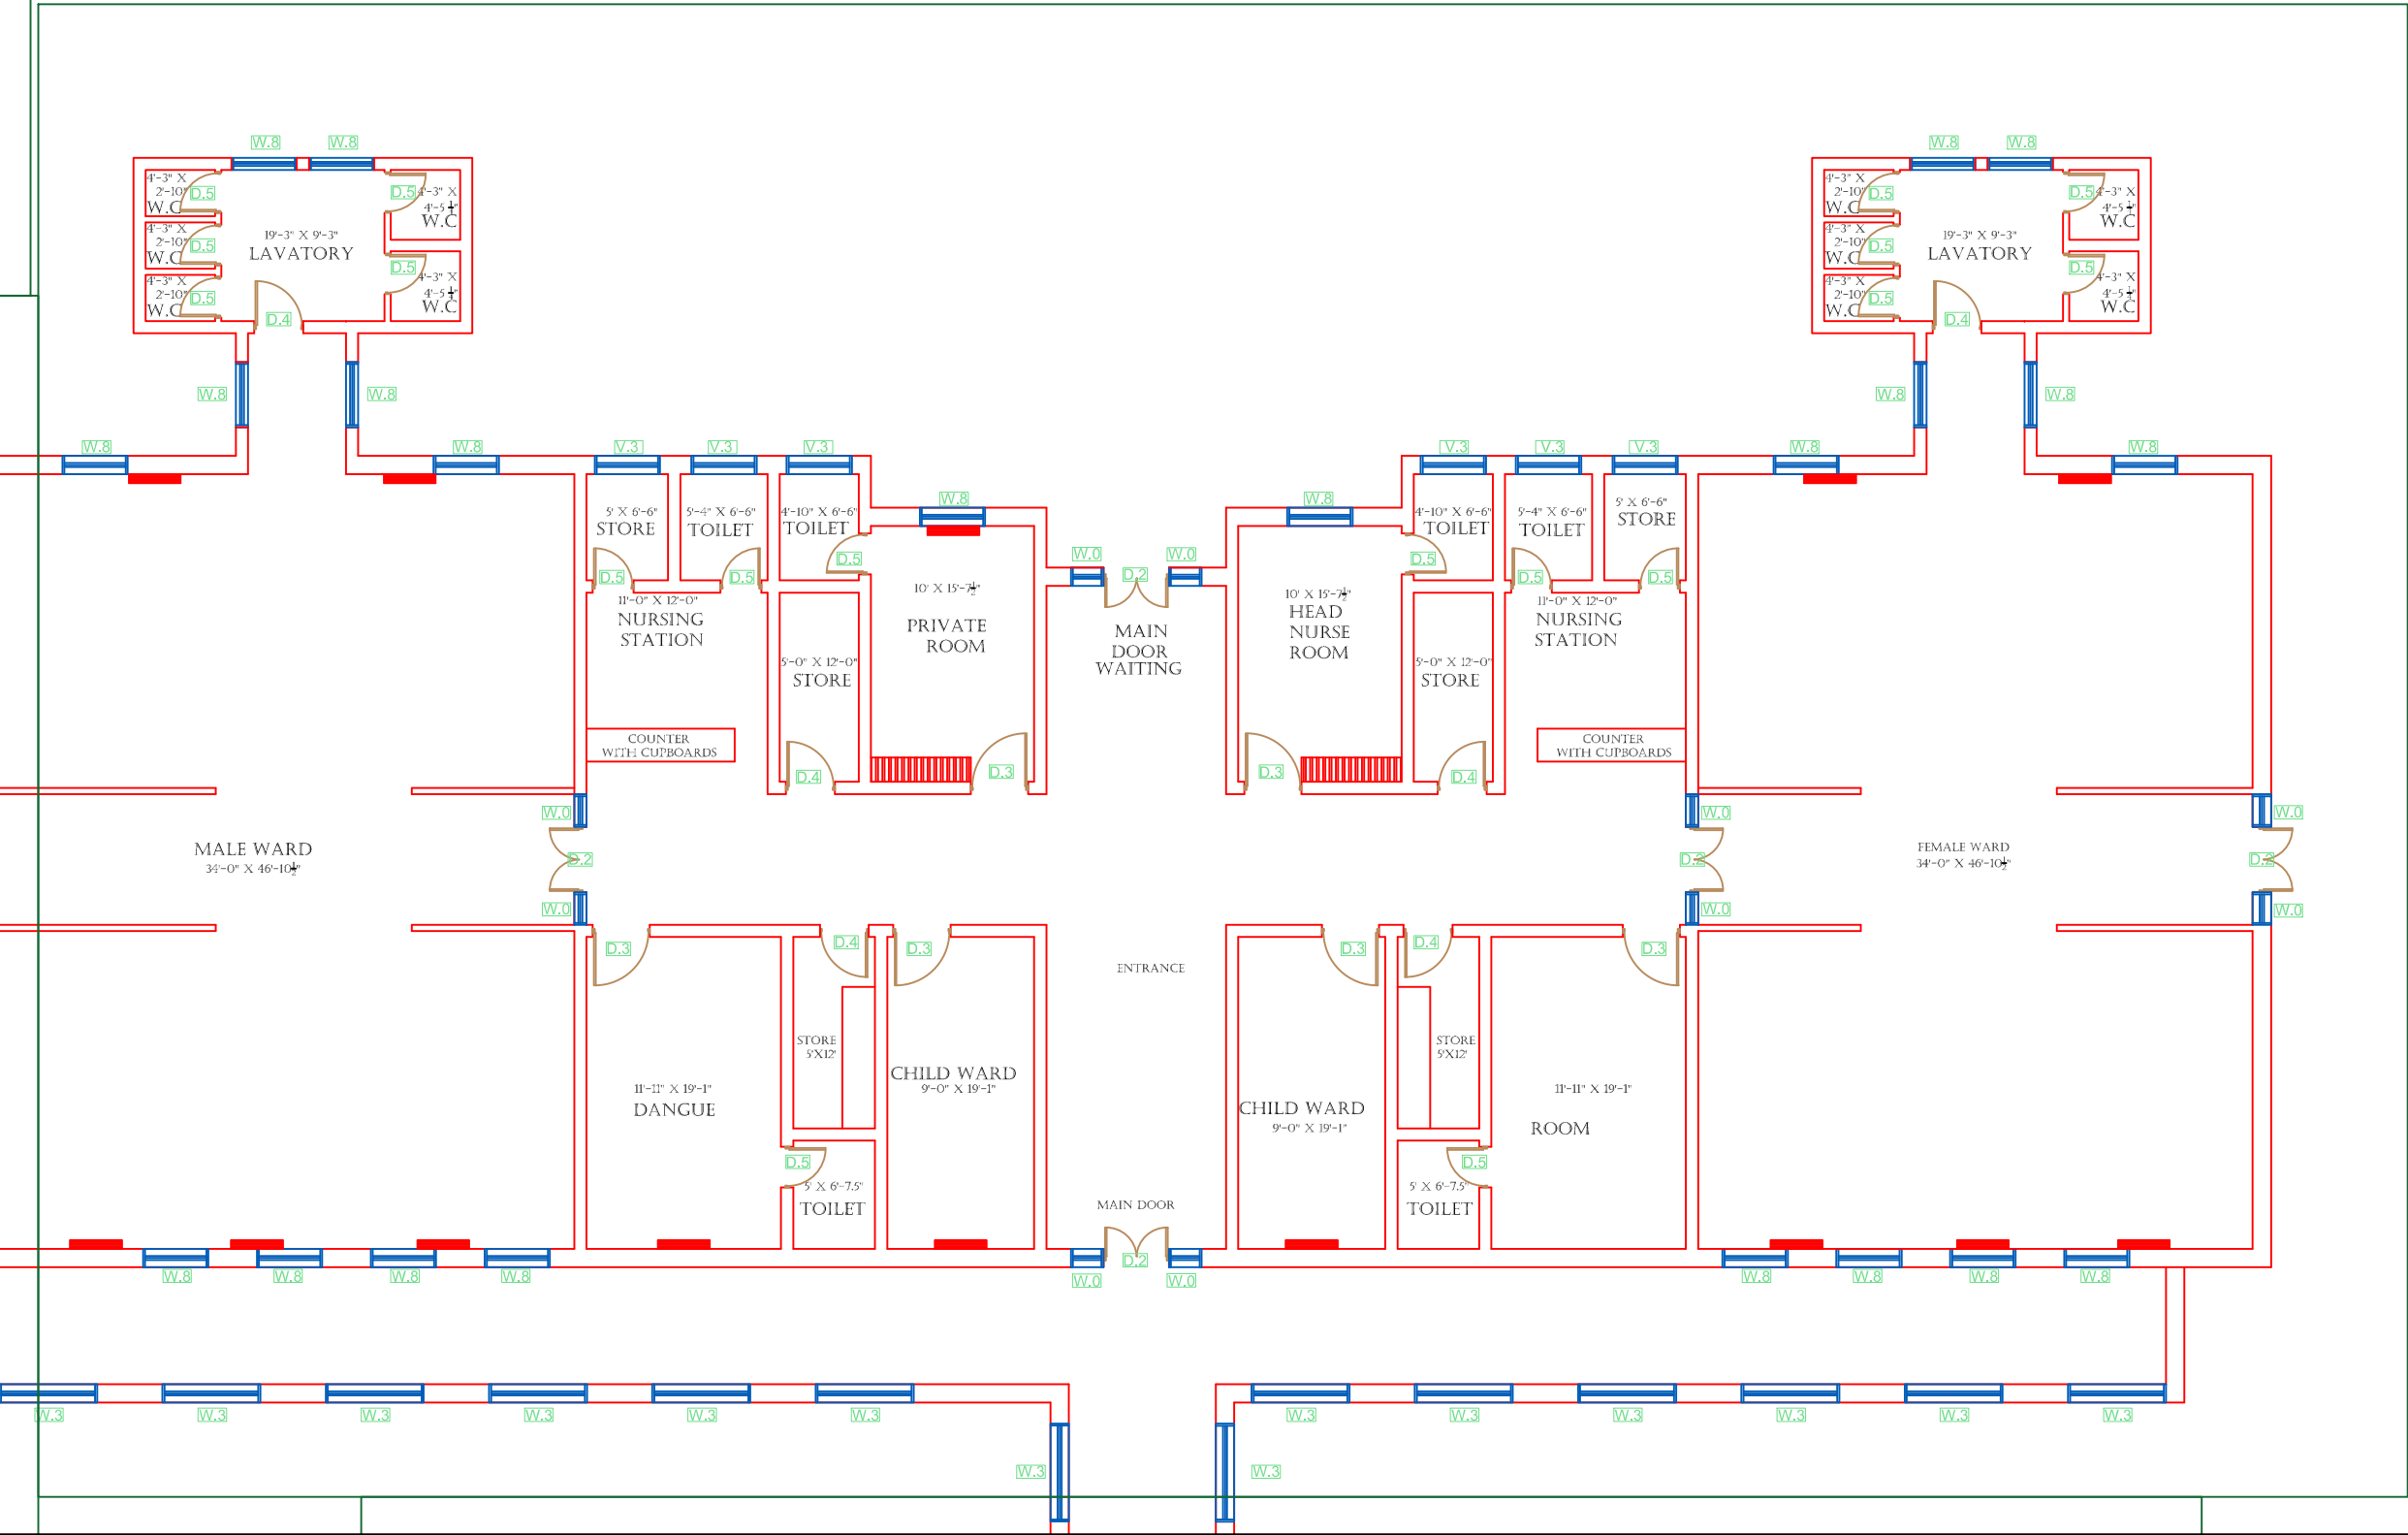

Legends:

Residential Area

Road

Wall

Power Line

OHT

Tree

Man Hole

Tube Well

Light Pole

Lawns

Earthen Areas

Asphalts Roads

Tough Pavers

P.C.C / Plinth Protection

Boundary Wall

Brick Pavers / Soling

Drain

Tap

Hand Pump

Air Conditioner

Tube Light

Fan

Roof Light

Bulb

AREA

AREA WITHIN BOUNDARY WALL 236175.48 SFT

AREA OF CLINICAL BLOCK 26582.258 SFT

PLINTH AREA OF BLOCK 26582.258 SFT

Project:

CAD MAPPING OF TEHSIL HEAD QUARTER HOSPITALS, PUNJAB

Client:

GOVERNMENT OF THE PUNJAB
PRIMARY & SECONDARY
HEALTHCARE DEPARTMENT

Consultant:

SKAFS CONSULTANT (Pvt.) Limited
ENGINEERING AND ENVIRONMENT
CONSULTANT

Drawing Title:


**THQ SOHAWA
CLINICAL BLOCK PLAN (PART 2)**

Drawing No.

SKAFS/SOHAWA /10

CLINICAL BLOCK OF THQ HOSPITAL SOHAWA

GROUND FLOOR PART 3

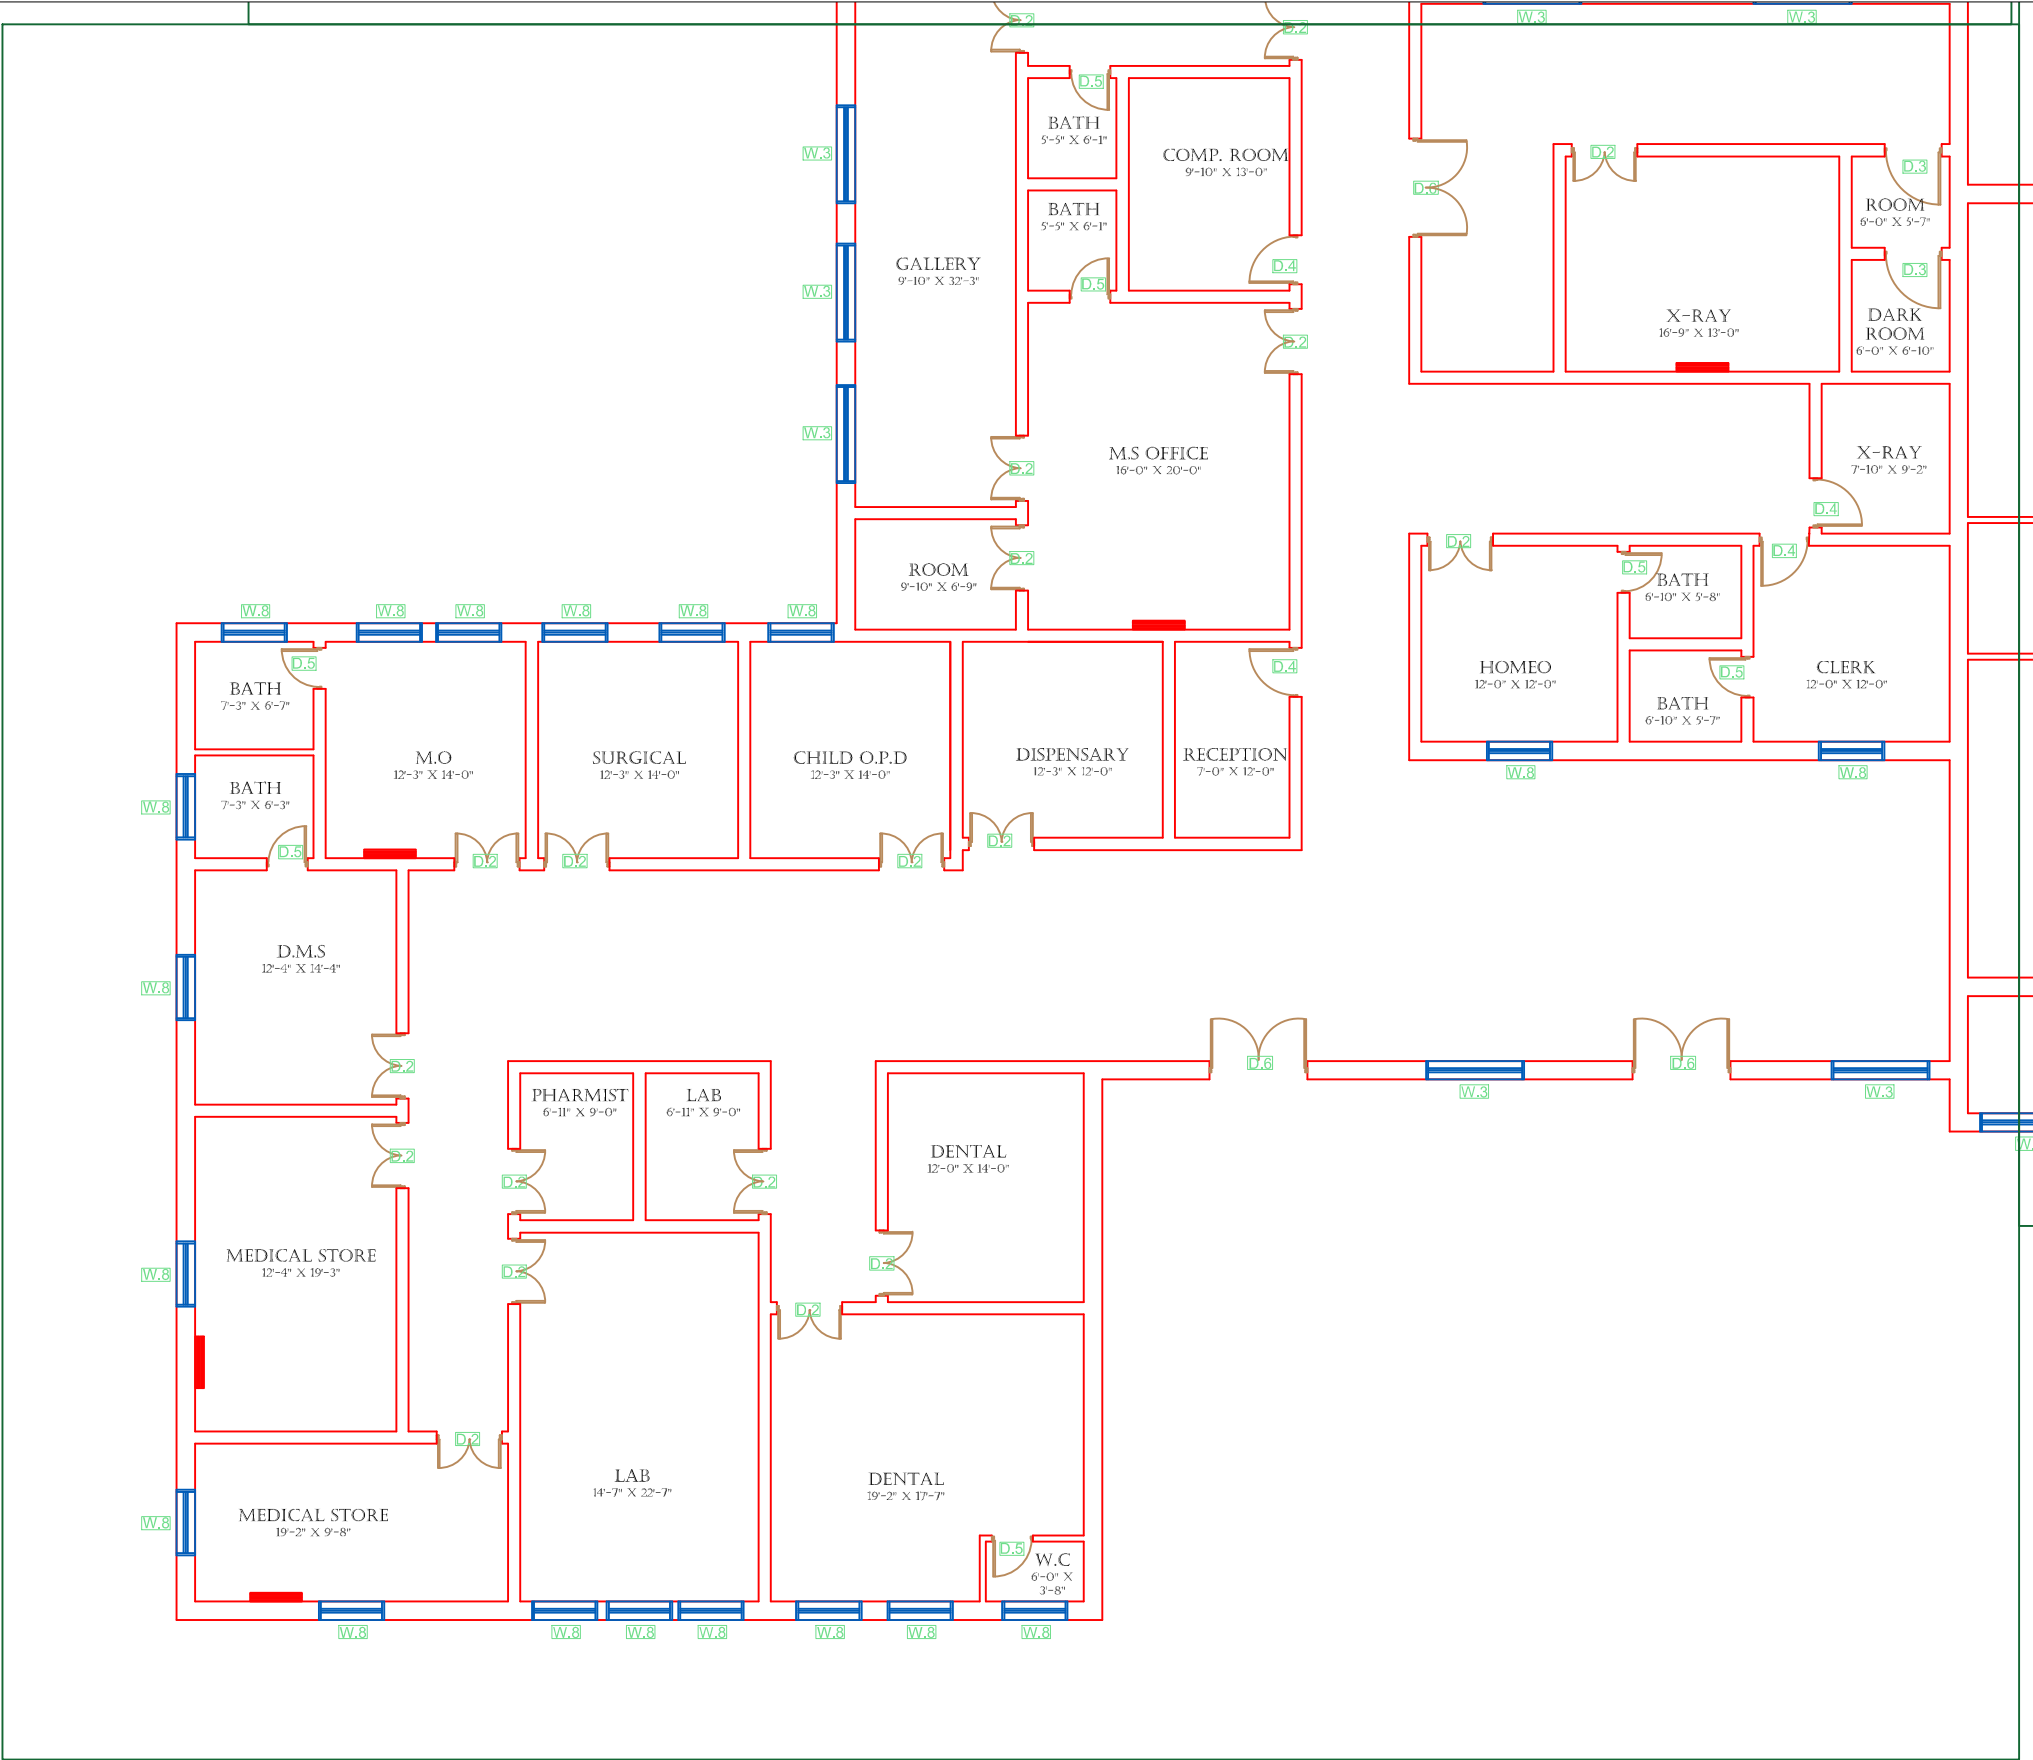

Project:
**CAD MAPPING OF TEHSIL
HEAD QUARTER HOSPITALS,
PUNJAB**

Client:

GOVERNMENT OF THE PUNJAB
PRIMARY & SECONDARY
HEALTHCARE DEPARTMENT

Consultant:


SKAFS CONSULTANT (Pvt.)
Limited
ENGINEERING AND ENVIRONMENT
CONSULTANT

Drawing Title:
**THQ SOHAWA
CLINICAL BLOCK PLAN (PART 3)**

Drawing No.
SKAFS/SOHAWA /11

CLINICAL BLOCK OF THQ HOSPITAL SOHAWA

GROUND FLOOR PART 4

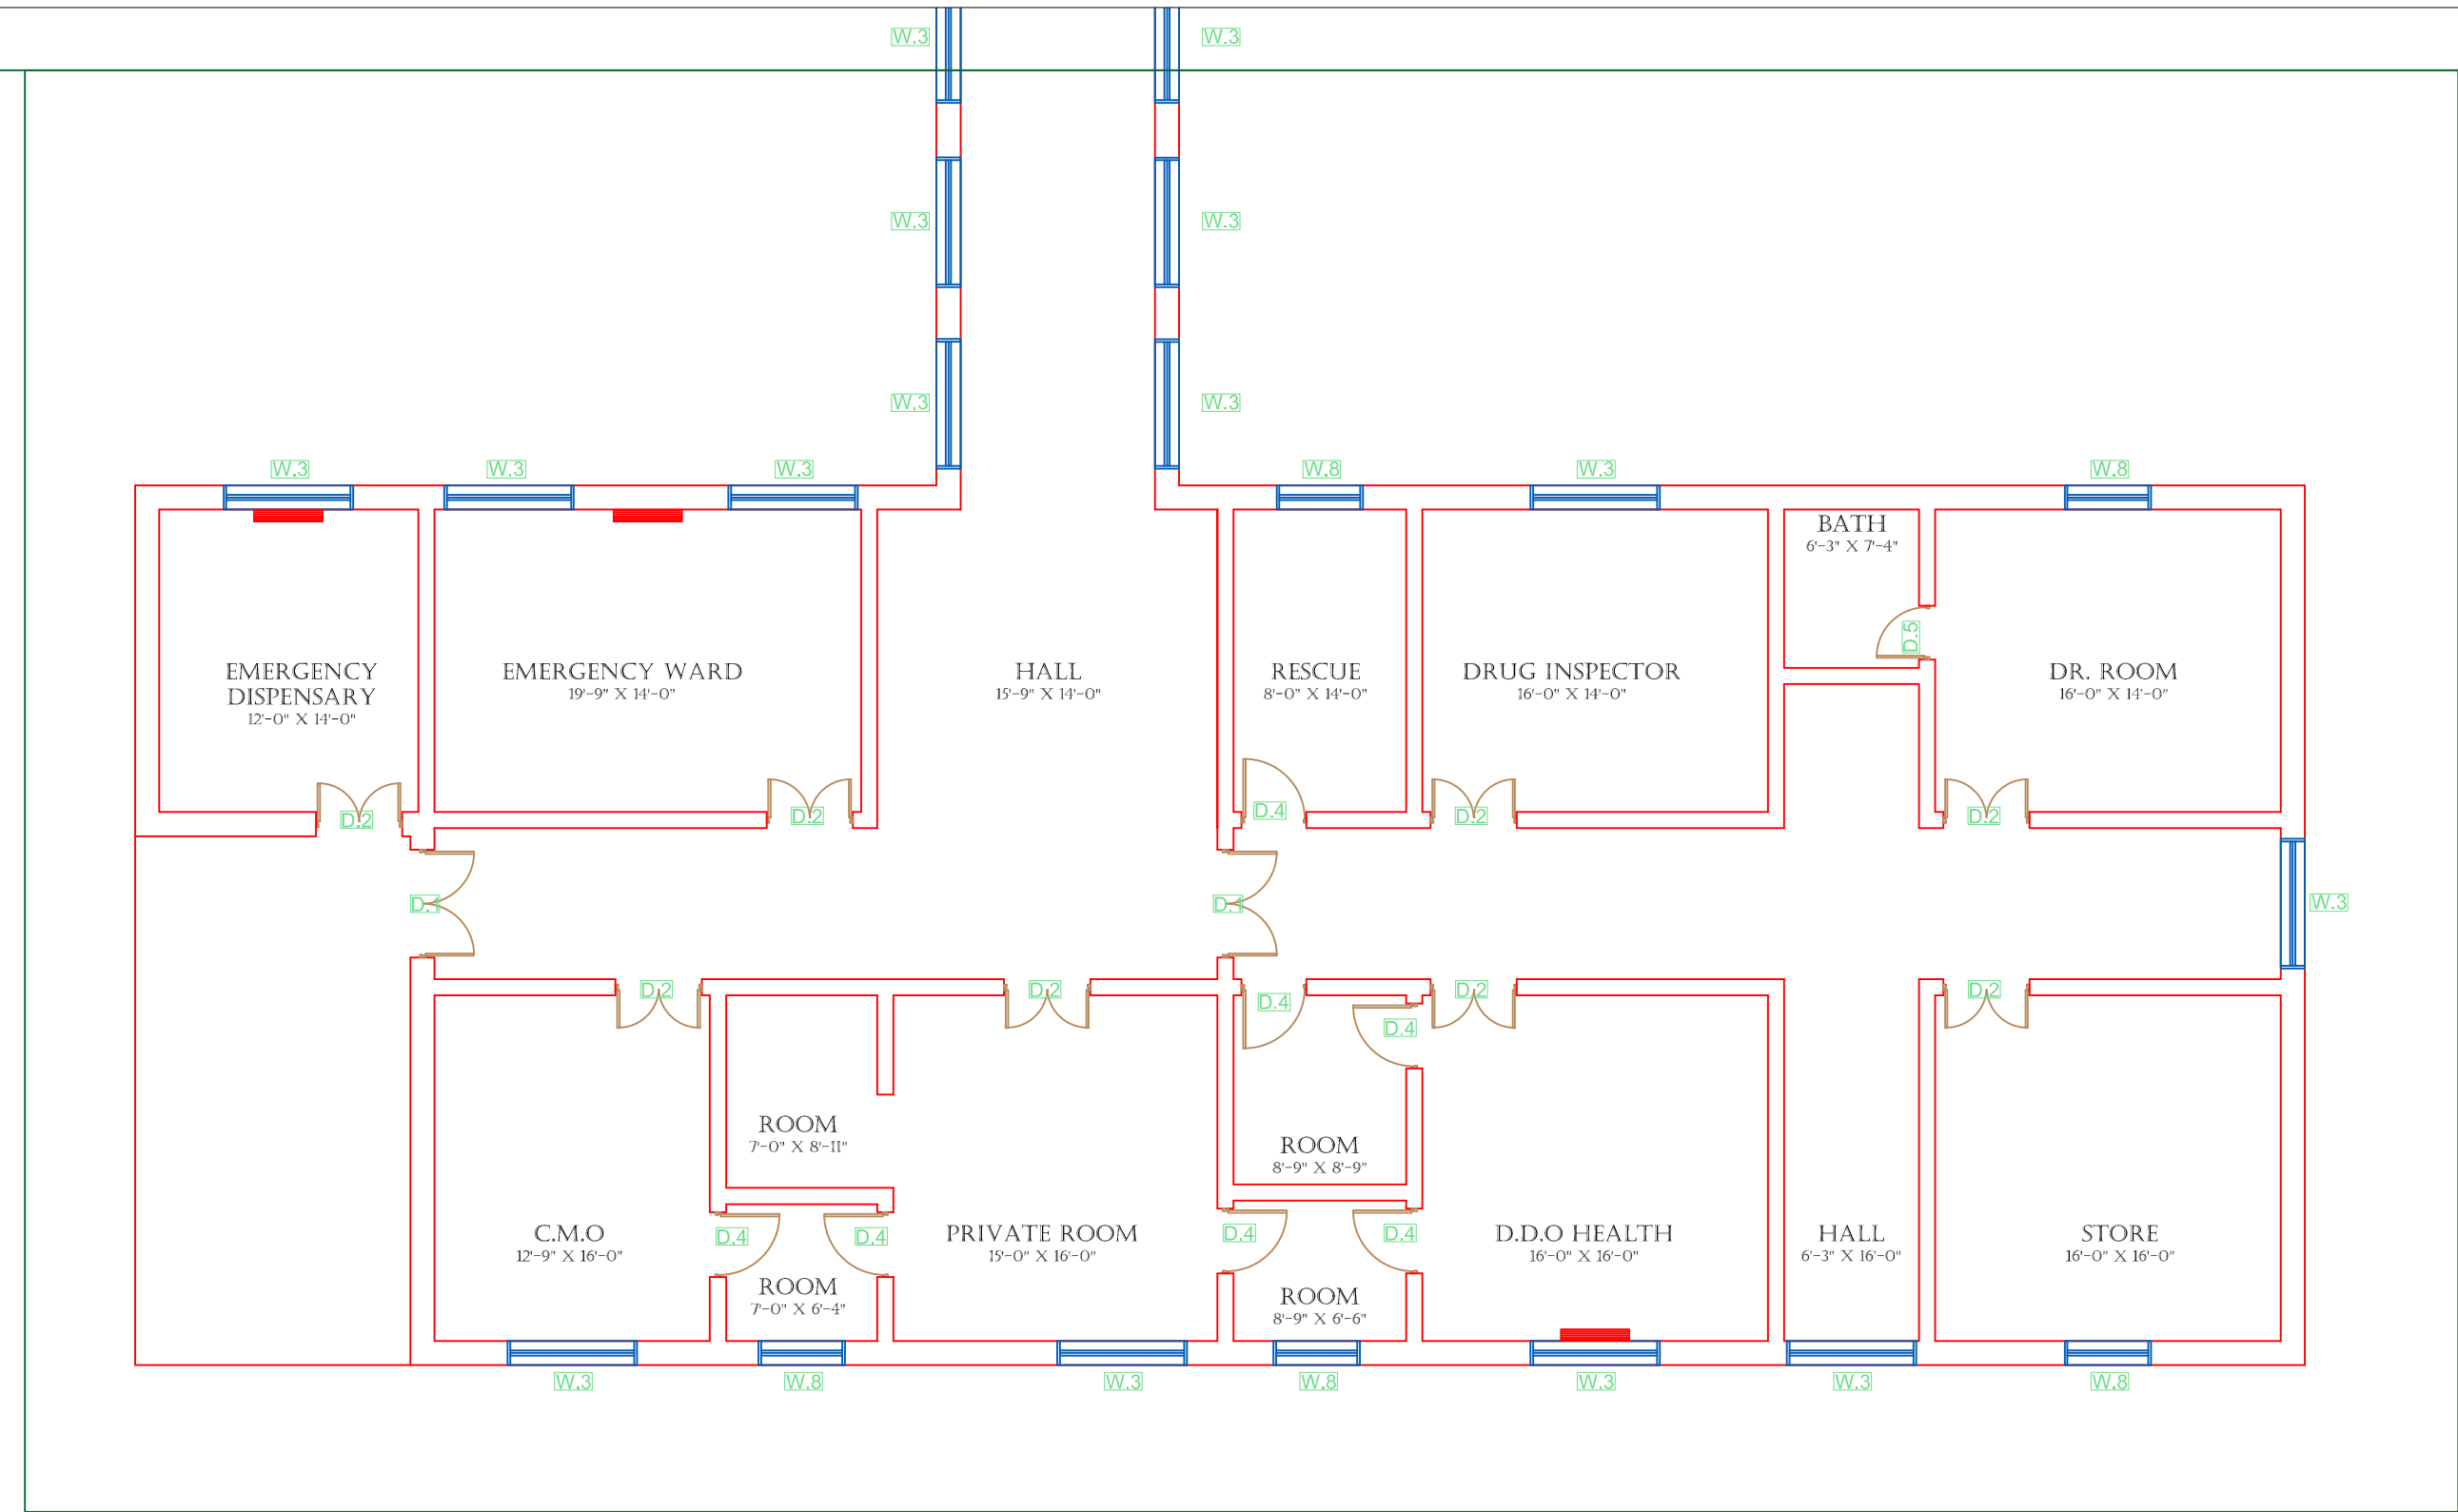

Legends:

Residential Area	
Road	
Wall	
Power Line	
OHT	
Tree	
Man Hole	
Tube Well	
Light Pole	
Lawns	
Earthen Areas	
Asphalts Roads	
Tough Pavers	
P.C.C / Plinth Protection	
Boundary Wall	
Brick Pavers / Soling	
Drain	
Tap	
Hand Pump	
Air Conditioner	
Tube Light	
Fan	
Roof Light	
Bulb	

AREA	
AREA WITHIN BOUNDARY WALL	236175.48 SFT
AREA OF CLINICAL BLOCK	26582.258 SFT
PLINTH AREA OF BLOCK	26582.258 SFT

OPENING SCHEDULE OF DOORS AND WINDOWS					
DOORS	WIDTH	HEIGHT	WINDOWS	WIDTH	HEIGHT
D1	5'-6"	7'-0"	W1	3'-0"	3'-0"
D2	5'-0"	7'-0"	W2	3'-6"	3'-6"
D3	4'-0"	7'-0"	W3	6'-0"	6'-0"
D4	3'-6"	7'-0"	W4	4'-6"	4'-6"
D5	3'-0"	7'-0"	W5	8'-6"	8'-6"
D6	2'-6"	7'-0"	W6	2'-6"	2'-6"
D7	6'-0"	7'-0"	W7	4'-0"	4'-0"
V1	1'-6"	1'-6"	W8	5'-0"	5'-0"
V2	2'-0"	2'-0"	W9	7'-0"	7'-0"

Project:
**CAD MAPPING OF TEHSIL
HEAD QUARTER HOSPITALS,
PUNJAB**


Client: GOVERNMENT OF THE PUNJAB PRIMARY & SECONDARY HEALTHCARE DEPARTMENT	Consultant: SKAFS CONSULTANT (Pvt.) Limited ENGINEERING AND ENVIRONMENT CONSULTANT
---	--

Drawing Title: **THQ SOHAWA
CLINICAL BLOCK PLAN (PART 4)**

Drawing No. **SKAFS/SOHAWA /12**

ELECTRICAL LAYOUT PLAN OF THQ HOSPITAL SOHAWA

GROUND FLOOR

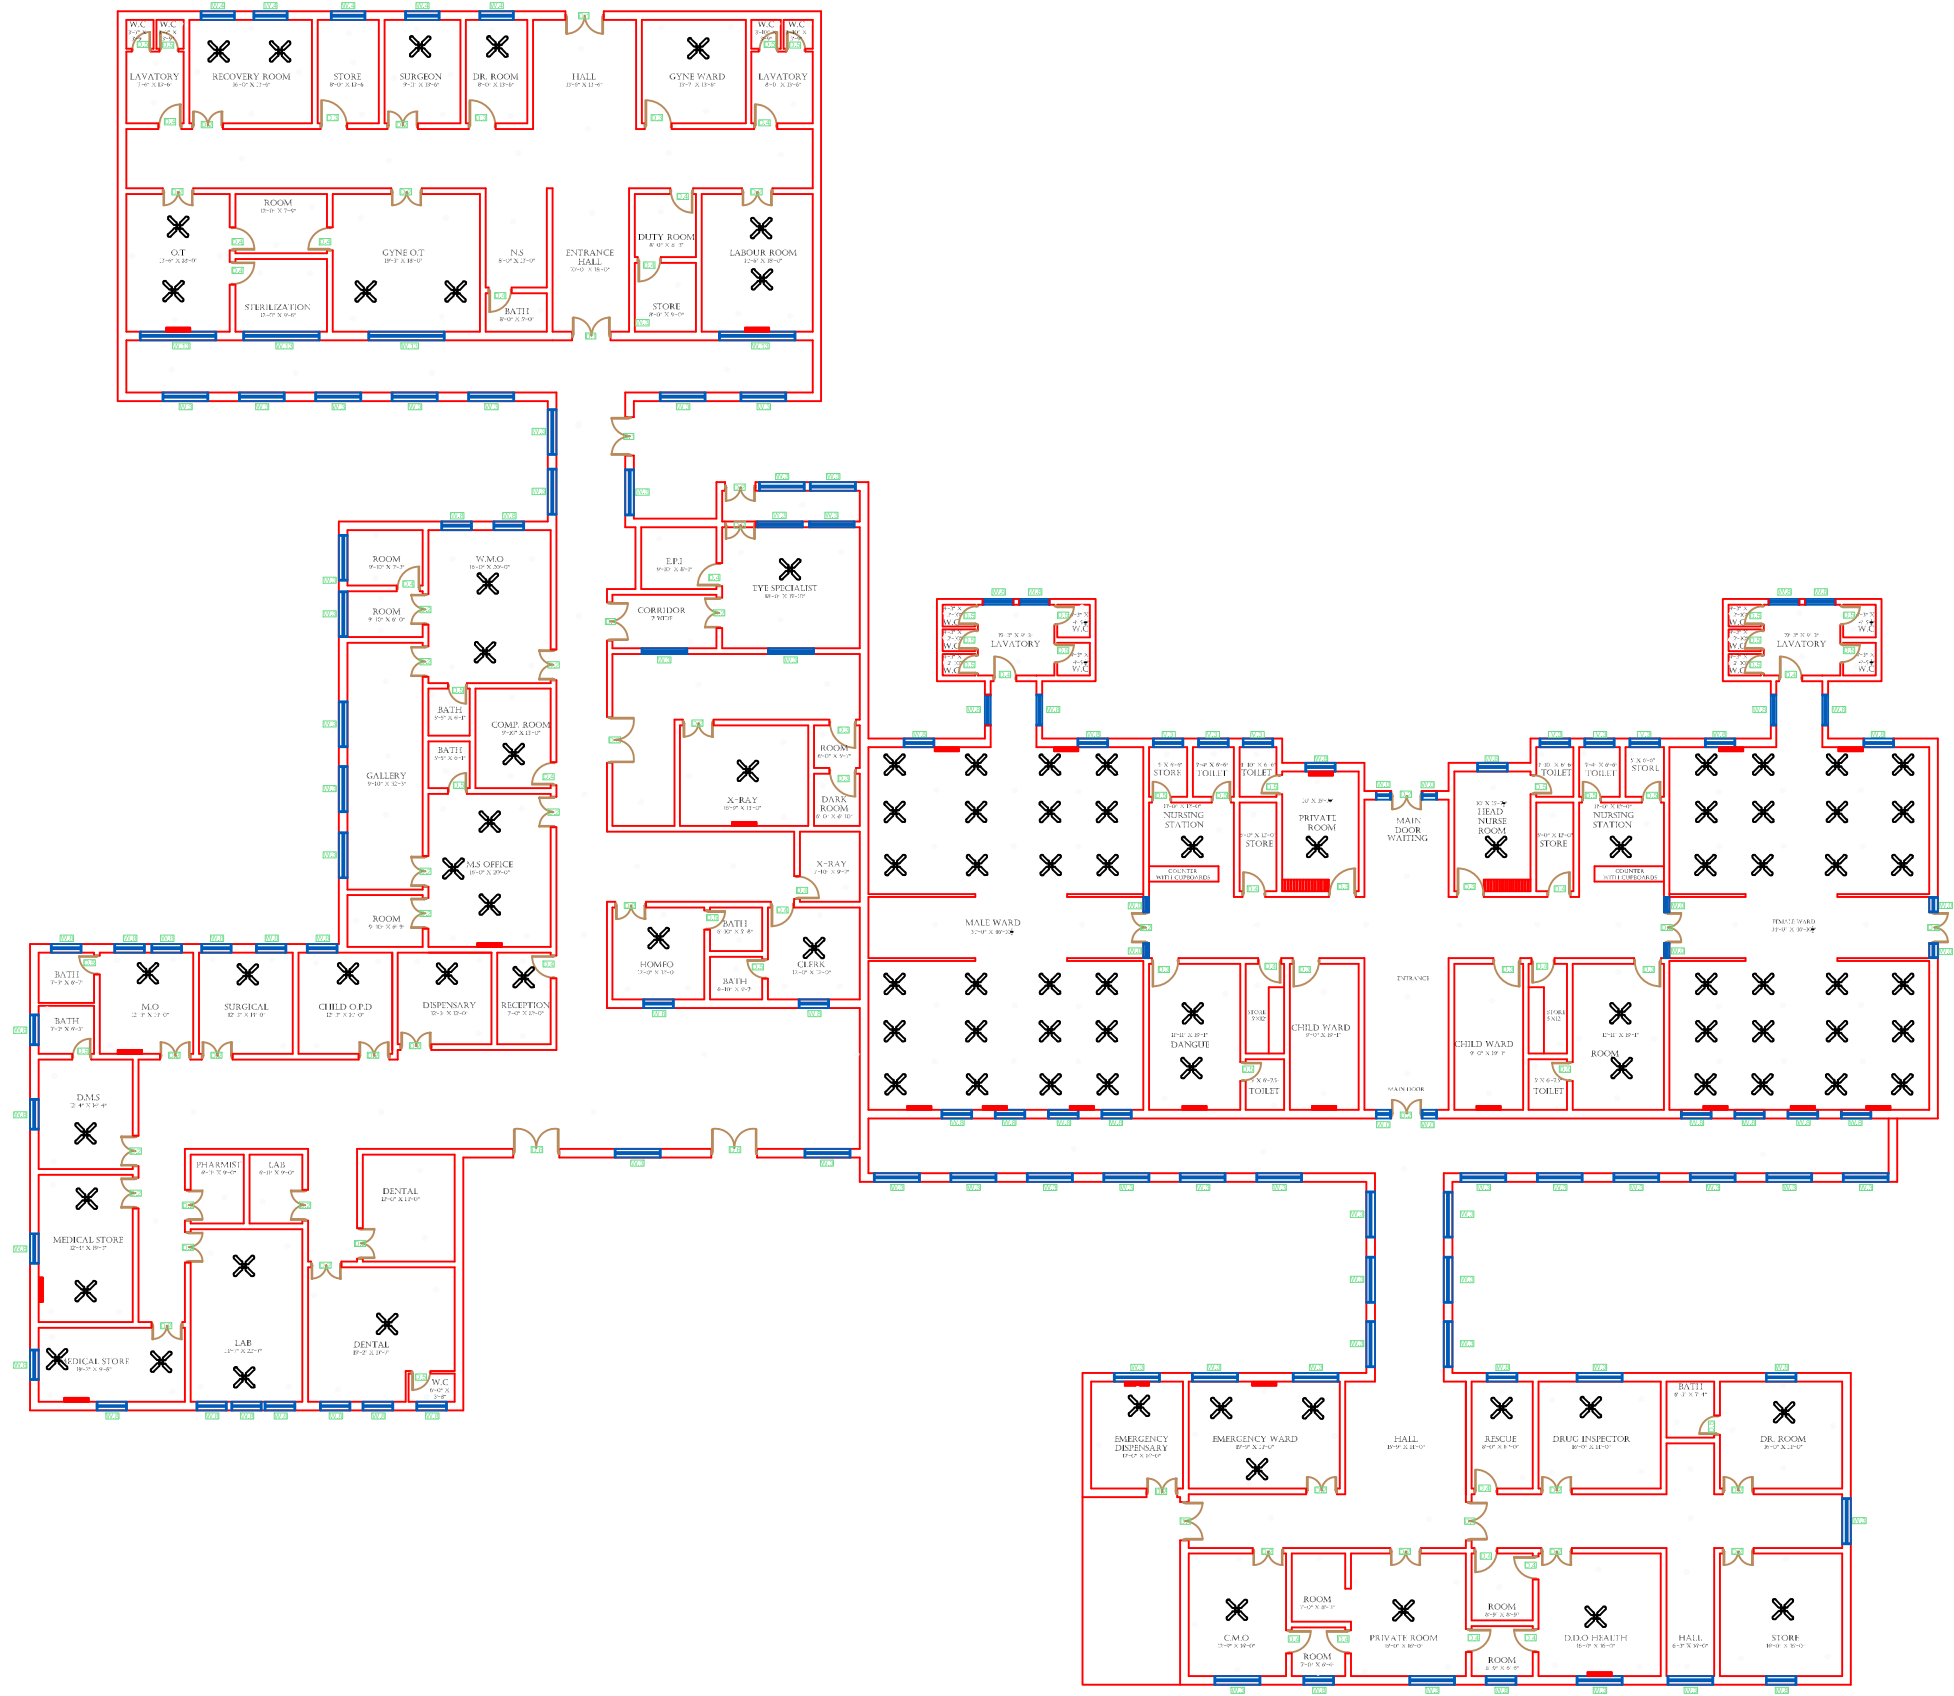

Legends:

Residential Area	
Road	
Wall	
Power Line	
OHT	
Tree	
Man Hole	
Tube Well	
Light Pole	
Lawns	
Earthen Areas	
Asphalts Roads	
Tough Pavers	
P.C.C / Plinth Protection	
Boundary Wall	
Brick Pavers / Soling	
Drain	
Tap	
Hand Pump	
Air Conditioner	
Tube Light	
Fan	
Roof Light	
Bulb	

AREA					
AREA WITHIN BOUNDARY WALL		236175.48 SFT			
AREA OF CLINICAL BLOCK		26582.258 SFT			
PLINTH AREA OF BLOCK		26582.258 SFT			

OPENING SCHEDULE OF DOORS AND WINDOWS					
DOORS	WIDTH	HEIGHT	WINDOWS	WIDTH	HEIGHT
D1	5'-6"	7'-0"	W1	3'-0"	3'-0"
D2	5'-0"	7'-0"	W2	3'-6"	3'-6"
D3	4'-0"	7'-0"	W3	6'-0"	6'-0"
D4	3'-6"	7'-0"	W4	4'-6"	4'-6"
D5	3'-0"	7'-0"	W5	8'-6"	8'-6"
D6	2'-6"	7'-0"	W6	2'-6"	2'-6"
D7	6'-0"	7'-0"	W7	4'-0"	4'-0"
V1	1'-6"	1'-6"	W8	5'-0"	5'-0"
V2	2'-0"	2'-0"	W9	7'-0"	7'-0"

Project:
CAD MAPPING OF TEHSIL
HEAD QUARTER HOSPITALS,
PUNJAB

Client:

GOVERNMENT OF THE PUNJAB
PRIMARY & SECONDARY
HEALTHCARE DEPARTMENT

Consultant:

SKAFS CONSULTANT (Pvt.)
Limited
ENGINEERING AND ENVIRONMENT
CONSULTANT

Drawing Title:
THQ SOHAWA
ELECTRICAL PLAN (GROUND FLOOR)

Drawing No.
SKAFS/SOHAWA /13