

MASTER PLAN OF THQ HOSPITAL CIVIL HOSPITAL MULTAN

PART 1

PART 2

PART 3

PART 4



**Legends:**

|                           |  |
|---------------------------|--|
| Residential Area          |  |
| Road                      |  |
| Wall                      |  |
| Power Line                |  |
| OHT                       |  |
| Tree                      |  |
| Man Hole                  |  |
| Tube Well                 |  |
| Light Pole                |  |
| Lawns                     |  |
| Earthen Areas             |  |
| Asphalts Roads            |  |
| Tough Pavers              |  |
| P.C.C / Plinth Protection |  |
| Boundary Wall             |  |
| Brick Pavers / Soling     |  |
| Drain                     |  |
| Tap                       |  |
| Hand Pump                 |  |
| Air Conditioner           |  |
| Tube Light                |  |
| Fan                       |  |
| Roof Light                |  |
| Bulb                      |  |

| AREA                      |  |               |  |  |  |
|---------------------------|--|---------------|--|--|--|
| AREA WITHIN BOUNDARY WALL |  | 46104.476 Sft |  |  |  |
| AREA OF CLINICAL BLOCK    |  | 18545.614 Sft |  |  |  |
| PLINTH AREA OF BLOCK      |  | 14944.413 Sft |  |  |  |

| OPENING SCHEDULE OF DOORS AND WINDOWS |       |        |         |       |        |
|---------------------------------------|-------|--------|---------|-------|--------|
| DOORS                                 | WIDTH | HEIGHT | WINDOWS | WIDTH | HEIGHT |
| D1                                    | 2'-0" | 7'-0"  | W1      | 3'-0" | 5'-0"  |
| D2                                    | 2'-6" | 7'-0"  | W2      | 4'-0" | 4'-0"  |
| D3                                    | 3'-0" | 7'-0"  | W3      | 6'-0" | 6'-0"  |
| D4                                    | 3'-6" | 7'-0"  | W4      | 8'-0" | 8'-0"  |
| D5                                    | 4'-0" | 7'-0"  | W5      | 5'-0" | 5'-0"  |
| D6                                    | 4'-6" | 7'-0"  | W6      |       |        |
| D7                                    | 5'-0" | 7'-0"  | W7      |       |        |
| D8                                    | 6'-0" | 7'-0"  | V1      | 2'-0" | 2'-0"  |
| D9                                    | 7'-0" | 7'-0"  | V2      |       |        |

Project: CAD MAPPING OF TEHSIL HEAD QUARTER HOSPITALS, PUNJAB

Client: GOVERNMENT OF THE PUNJAB  
PRIMARY & SECONDARY  
HEALTHCARE DEPARTMENT



Consultant: SKAFS CONSULTANT (Pvt.)  
Limited  
ENGINEERING AND ENVIRONMENT  
CONSULTANT

Drawing Title: THQ CIVIL HOSPITAL MULTAN  
HOSPITAL MASTER PLAN

Drawing No. SKAFS/CIVIL-H-MULTAN /03

# MASTER PLAN OF THQ HOSPITAL CIVIL HOSPITAL MULTAN

## PART 1

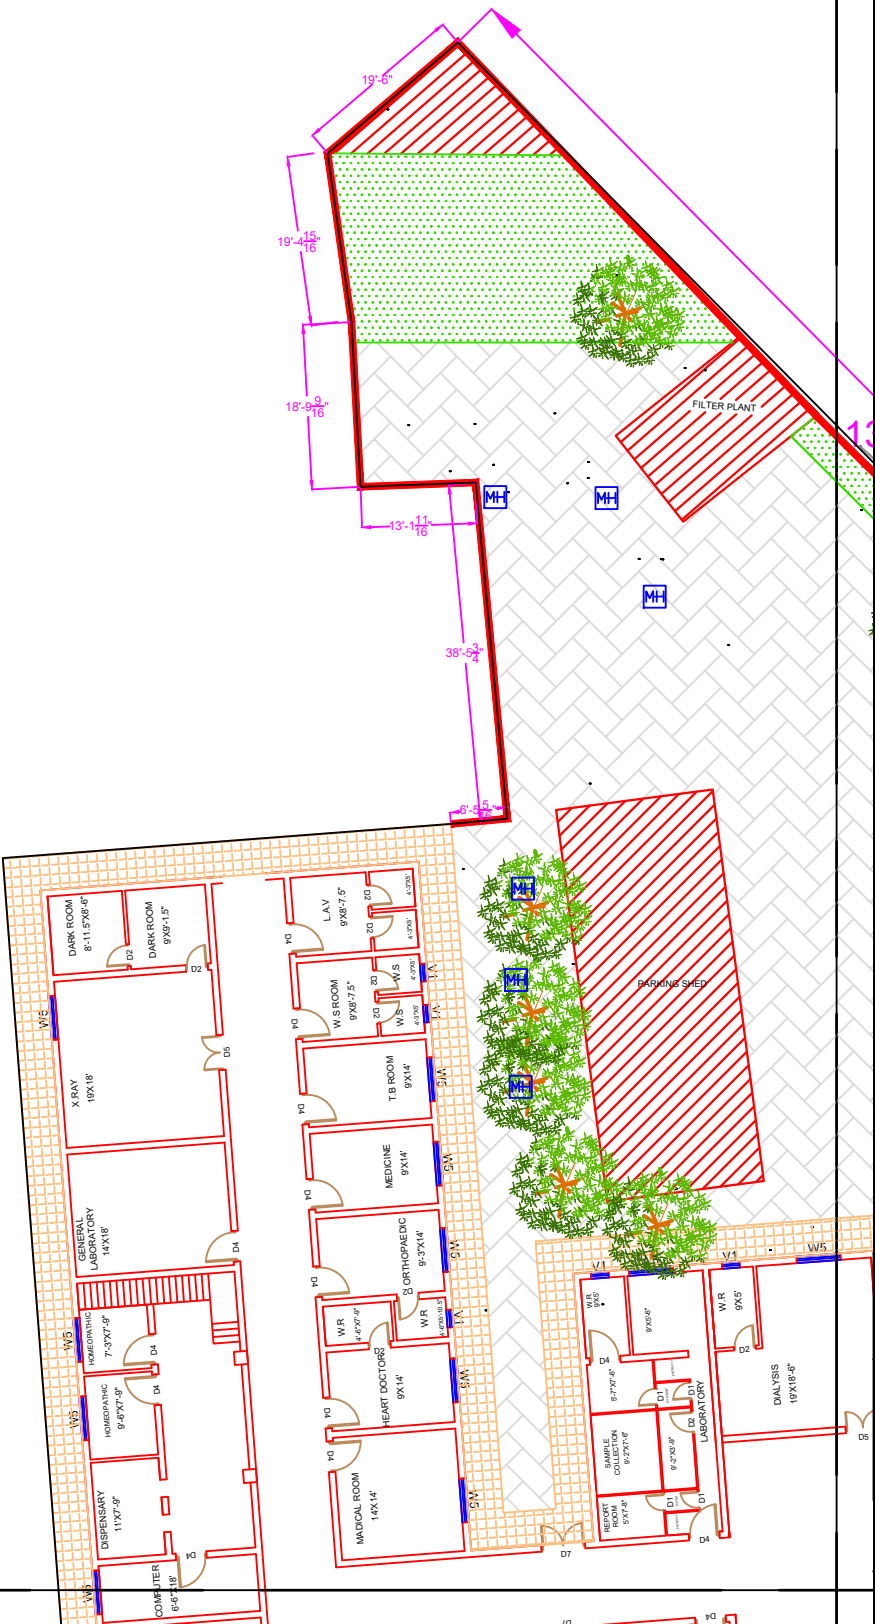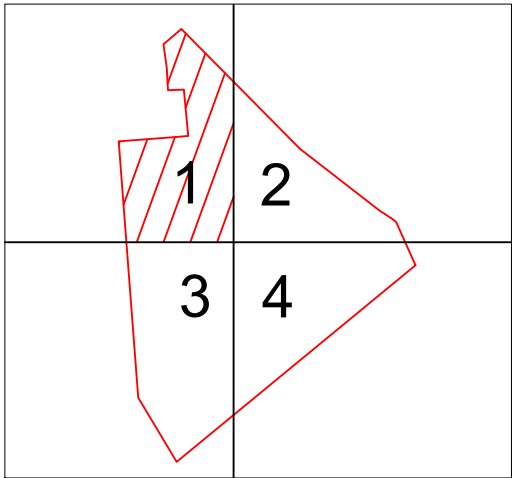

| Legends:                  |  |
|---------------------------|--|
| Residential Area          |  |
| Road                      |  |
| Wall                      |  |
| Power Line                |  |
| OHT                       |  |
| Tree                      |  |
| Man Hole                  |  |
| Tube Well                 |  |
| Light Pole                |  |
| Lawns                     |  |
| Earthen Areas             |  |
| Asphalts Roads            |  |
| Tough Pavers              |  |
| P.C.C / Plinth Protection |  |
| Boundary Wall             |  |
| Brick Pavers / Soling     |  |
| Drain                     |  |
| Tap                       |  |
| Hand Pump                 |  |
| Air Conditioner           |  |
| Tube Light                |  |
| Fan                       |  |
| Roof Light                |  |
| Bulb                      |  |

| AREA                      |               |
|---------------------------|---------------|
| AREA WITHIN BOUNDARY WALL | 46104.476 Sft |
| AREA OF CLINICAL BLOCK    | 18545.614 Sft |
| PLINTH AREA OF BLOCK      | 14944.413 Sft |

| OPENING SCHEDULE OF DOORS AND WINDOWS |       |        |         |       |        |
|---------------------------------------|-------|--------|---------|-------|--------|
| DOORS                                 | WIDTH | HEIGHT | WINDOWS | WIDTH | HEIGHT |
| D1                                    | 2'-0" | 7'-0"  | W1      | 3'-0" | 5'-0"  |
| D2                                    | 2'-6" | 7'-0"  | W2      | 4'-0" | 4'-0"  |
| D3                                    | 3'-0" | 7'-0"  | W3      | 6'-0" | 6'-0"  |
| D4                                    | 3'-6" | 7'-0"  | W4      | 8'-0" | 8'-0"  |
| D5                                    | 4'-0" | 7'-0"  | W5      | 5'-0" | 5'-0"  |
| D6                                    | 4'-6" | 7'-0"  | W6      |       |        |
| D7                                    | 5'-0" | 7'-0"  | W7      |       |        |
| D8                                    | 6'-0" | 7'-0"  | V1      | 2'-0" | 2'-0"  |
| D9                                    | 7'-0" | 7'-0"  | V2      |       |        |



|                                                                                         |                                                                                                    |
|-----------------------------------------------------------------------------------------|----------------------------------------------------------------------------------------------------|
| Project:<br><b>CAD MAPPING OF TEHSIL<br/>HEAD QUARTER HOSPITALS,<br/>PUNJAB</b>         |                                                                                                    |
| Client:<br><br>GOVERNMENT OF THE PUNJAB<br>PRIMARY & SECONDARY<br>HEALTHCARE DEPARTMENT | Consultant:<br><br>SKAFS CONSULTANT (Pvt.)<br>Limited<br>ENGINEERING AND ENVIRONMENT<br>CONSULTANT |

Drawing Title:  
**THQ CIVIL HOSPITAL MULTAN  
HOSPITAL MASTER PLAN PART 1**

Drawing No.  
**SKAFS/CIVIL-H-MULTAN /04**

# MASTER PLAN OF THQ HOSPITAL CIVIL HOSPITAL MULTAN

## PART 2

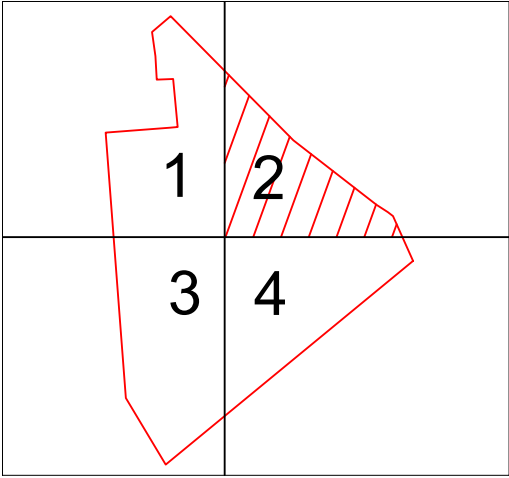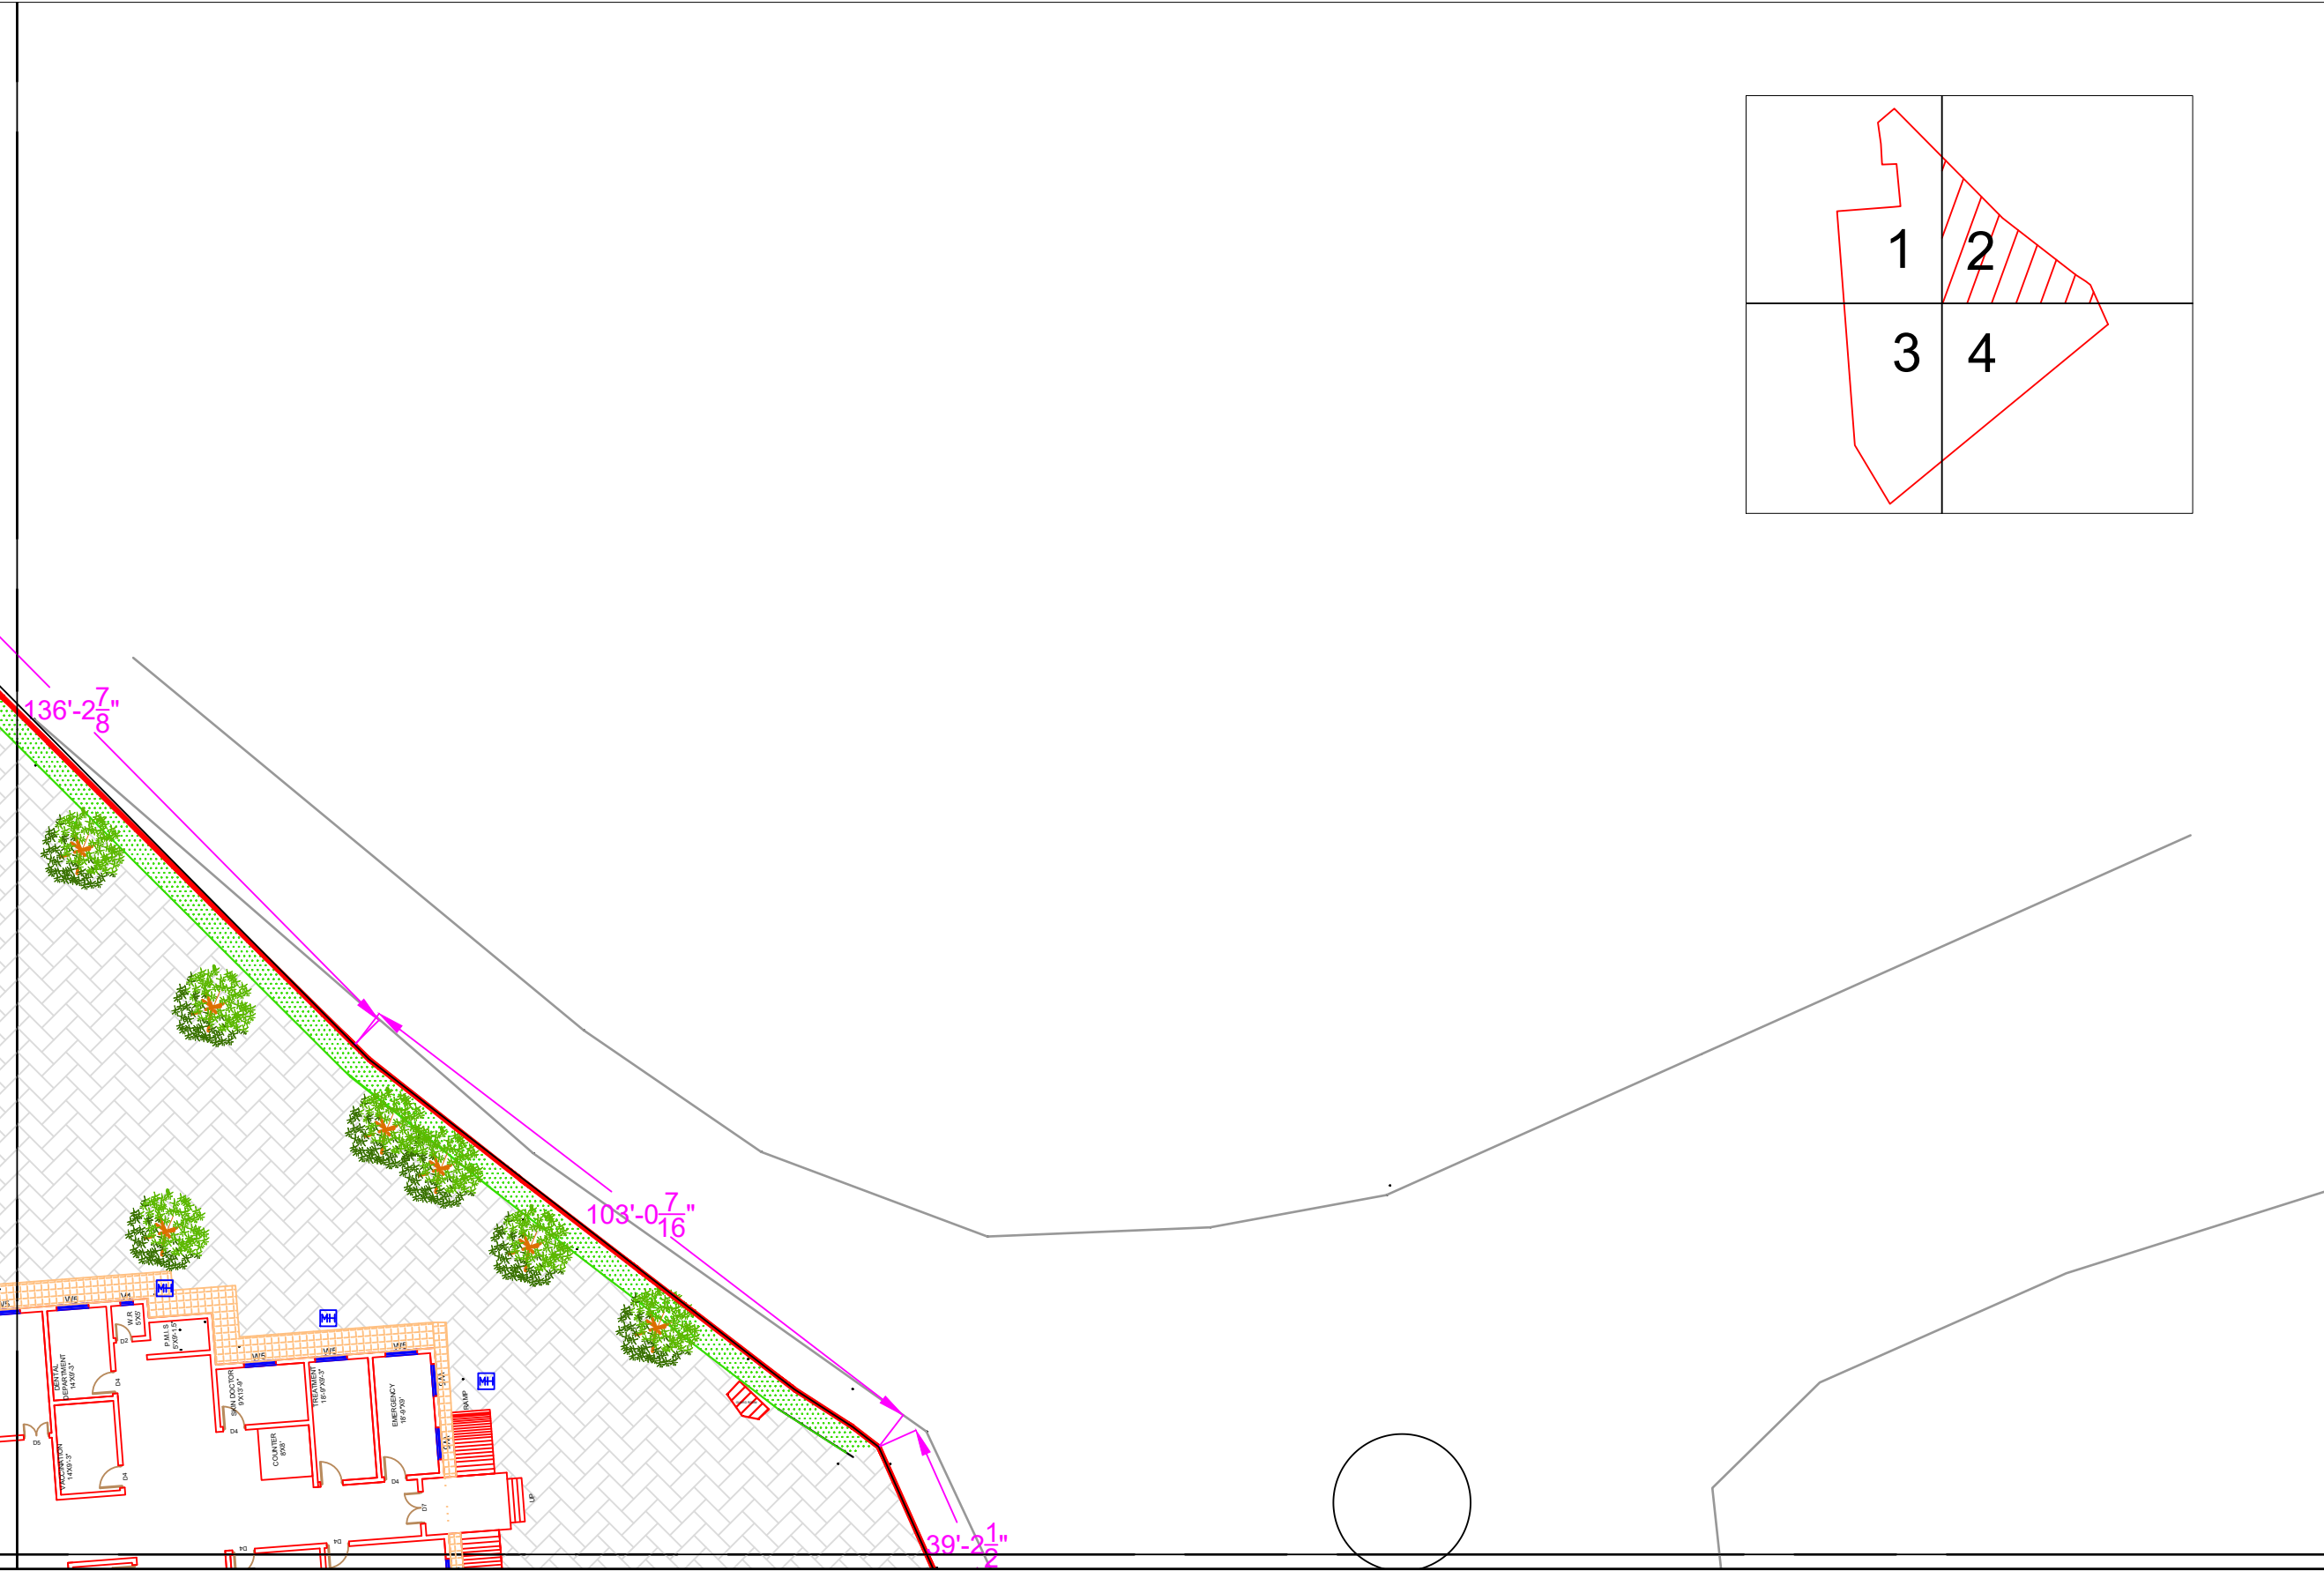

**Legends:**

|                           |  |
|---------------------------|--|
| Residential Area          |  |
| Road                      |  |
| Wall                      |  |
| Power Line                |  |
| OHT                       |  |
| Tree                      |  |
| Man Hole                  |  |
| Tube Well                 |  |
| Light Pole                |  |
| Lawns                     |  |
| Earthen Areas             |  |
| Asphalts Roads            |  |
| Tough Pavers              |  |
| P.C.C / Plinth Protection |  |
| Boundary Wall             |  |
| Brick Pavers / Soling     |  |
| Drain                     |  |
| Tap                       |  |
| Hand Pump                 |  |
| Air Conditioner           |  |
| Tube Light                |  |
| Fan                       |  |
| Roof Light                |  |
| Bulb                      |  |

**AREA**

|                           |               |
|---------------------------|---------------|
| AREA WITHIN BOUNDARY WALL | 46104.476 Sft |
| AREA OF CLINICAL BLOCK    | 18545.614 Sft |
| PLINTH AREA OF BLOCK      | 14944.413 Sft |

**OPENING SCHEDULE OF DOORS AND WINDOWS**

| DOORS | WIDTH | HEIGHT | WINDOWS | WIDTH | HEIGHT |
|-------|-------|--------|---------|-------|--------|
| D1    | 2'-0" | 7'-0"  | W1      | 3'-0" | 5'-0"  |
| D2    | 2'-6" | 7'-0"  | W2      | 4'-0" | 4'-0"  |
| D3    | 3'-0" | 7'-0"  | W3      | 6'-0" | 6'-0"  |
| D4    | 3'-6" | 7'-0"  | W4      | 8'-0" | 8'-0"  |
| D5    | 4'-0" | 7'-0"  | W5      | 5'-0" | 5'-0"  |
| D6    | 4'-6" | 7'-0"  | W6      |       |        |
| D7    | 5'-0" | 7'-0"  | W7      |       |        |
| D8    | 6'-0" | 7'-0"  | V1      | 2'-0" | 2'-0"  |
| D9    | 7'-0" | 7'-0"  | V2      |       |        |

**Project:**  
**CAD MAPPING OF TEHSIL  
HEAD QUARTER HOSPITALS,  
PUNJAB**



|                                                                                                |                                                                                                           |
|------------------------------------------------------------------------------------------------|-----------------------------------------------------------------------------------------------------------|
| <b>Client:</b><br><br>GOVERNMENT OF THE PUNJAB<br>PRIMARY & SECONDARY<br>HEALTHCARE DEPARTMENT | <b>Consultant:</b><br><br>SKAFS CONSULTANT (Pvt.)<br>Limited<br>ENGINEERING AND ENVIRONMENT<br>CONSULTANT |
|------------------------------------------------------------------------------------------------|-----------------------------------------------------------------------------------------------------------|

**Drawing Title:**  
**THQ CIVIL HOSPITAL MULTAN  
HOSPITAL MASTER PLAN PART 2**

**Drawing No.**  
**SKAFS/CIVIL-H-MULTAN /05**

# MASTER PLAN OF THQ HOSPITAL CIVIL HOSPITAL MULTAN

## PART 3

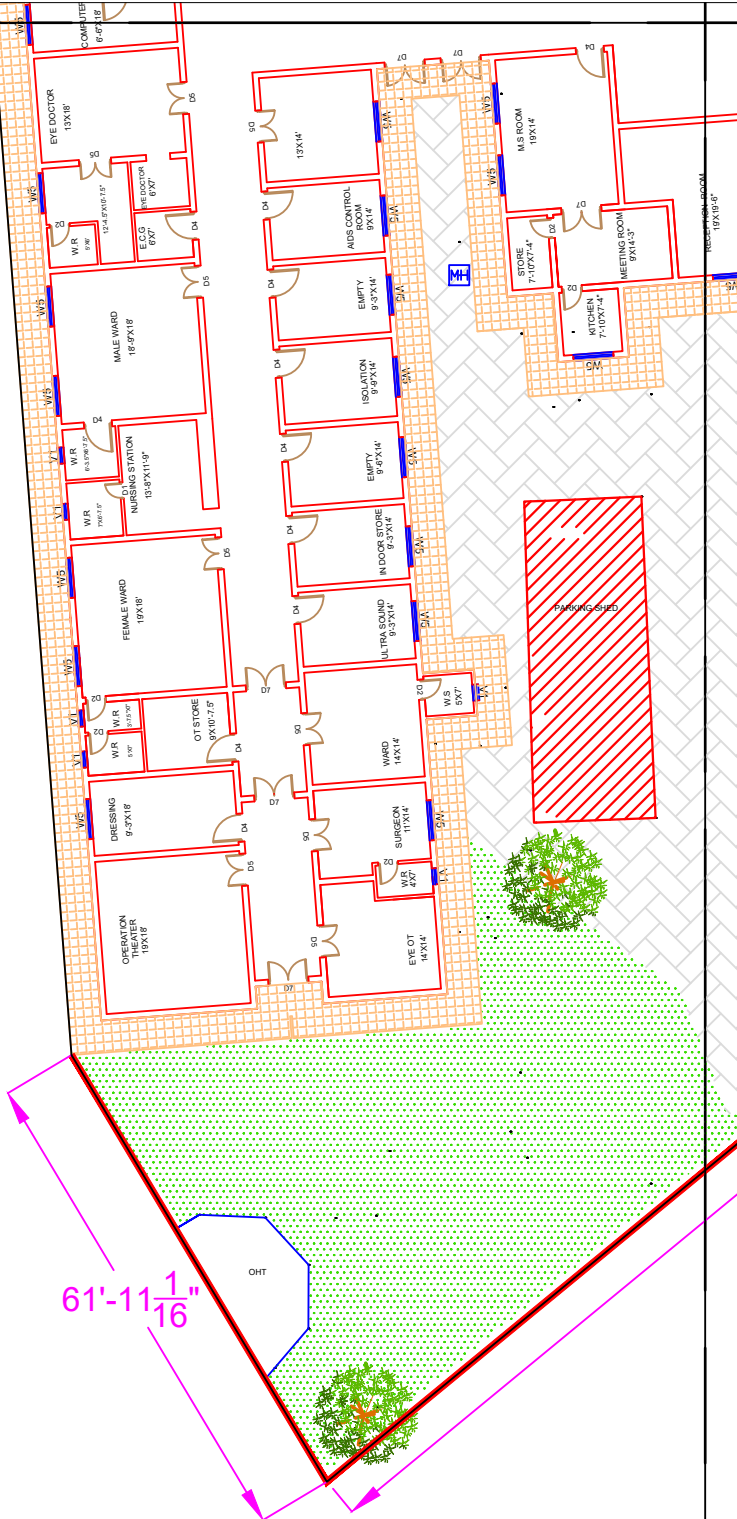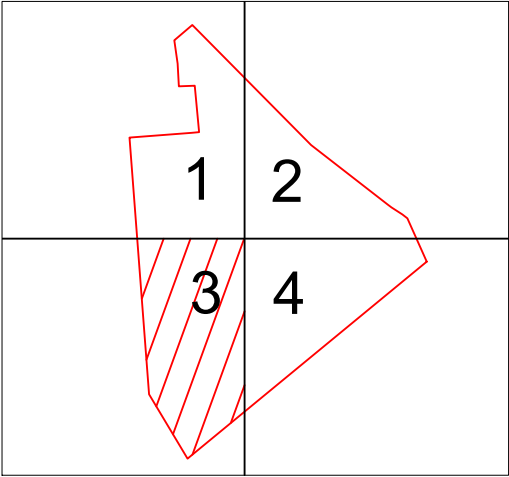

| Legends:                  |  |
|---------------------------|--|
| Residential Area          |  |
| Road                      |  |
| Wall                      |  |
| Power Line                |  |
| OHT                       |  |
| Tree                      |  |
| Man Hole                  |  |
| Tube Well                 |  |
| Light Pole                |  |
| Lawns                     |  |
| Earthen Areas             |  |
| Asphalts Roads            |  |
| Tough Pavers              |  |
| P.C.C / Plinth Protection |  |
| Boundary Wall             |  |
| Brick Pavers / Soling     |  |
| Drain                     |  |
| Tap                       |  |
| Hand Pump                 |  |
| Air Conditioner           |  |
| Tube Light                |  |
| Fan                       |  |
| Roof Light                |  |
| Bulb                      |  |


| AREA                      |               |
|---------------------------|---------------|
| AREA WITHIN BOUNDARY WALL | 46104.476 Sft |
| AREA OF CLINICAL BLOCK    | 18545.614 Sft |
| PLINTH AREA OF BLOCK      | 14944.413 Sft |

| OPENING SCHEDULE OF DOORS AND WINDOWS |       |        |         |       |        |
|---------------------------------------|-------|--------|---------|-------|--------|
| DOORS                                 | WIDTH | HEIGHT | WINDOWS | WIDTH | HEIGHT |
| D1                                    | 2'-0" | 7'-0"  | W1      | 3'-0" | 5'-0"  |
| D2                                    | 2'-6" | 7'-0"  | W2      | 4'-0" | 4'-0"  |
| D3                                    | 3'-0" | 7'-0"  | W3      | 6'-0" | 6'-0"  |
| D4                                    | 3'-6" | 7'-0"  | W4      | 8'-0" | 8'-0"  |
| D5                                    | 4'-0" | 7'-0"  | W5      | 5'-0" | 5'-0"  |
| D6                                    | 4'-6" | 7'-0"  | W6      |       |        |
| D7                                    | 5'-0" | 7'-0"  | W7      |       |        |
| D8                                    | 6'-0" | 7'-0"  | V1      | 2'-0" | 2'-0"  |
| D9                                    | 7'-0" | 7'-0"  | V2      |       |        |

|                                                                              |                                                                                     |
|------------------------------------------------------------------------------|-------------------------------------------------------------------------------------|
| Project:                                                                     |                                                                                     |
| CAD MAPPING OF TEHSIL HEAD QUARTER HOSPITALS, PUNJAB                         |                                                                                     |
| Client:                                                                      | Consultant:                                                                         |
| <br>GOVERNMENT OF THE PUNJAB<br>PRIMARY & SECONDARY<br>HEALTHCARE DEPARTMENT | <br>SKAFS CONSULTANT (Pvt.)<br>Limited<br>ENGINEERING AND ENVIRONMENT<br>CONSULTANT |
| Drawing Title:                                                               |                                                                                     |
| THQ CIVIL HOSPITAL MULTAN<br>HOSPITAL MASTER PLAN PART 3                     |                                                                                     |
| Drawing No.                                                                  |                                                                                     |
| SKAFS/CIVIL-H-MULTAN /06                                                     |                                                                                     |

# MASTER PLAN OF THQ HOSPITAL CIVIL HOSPITAL MULTAN

## PART 4

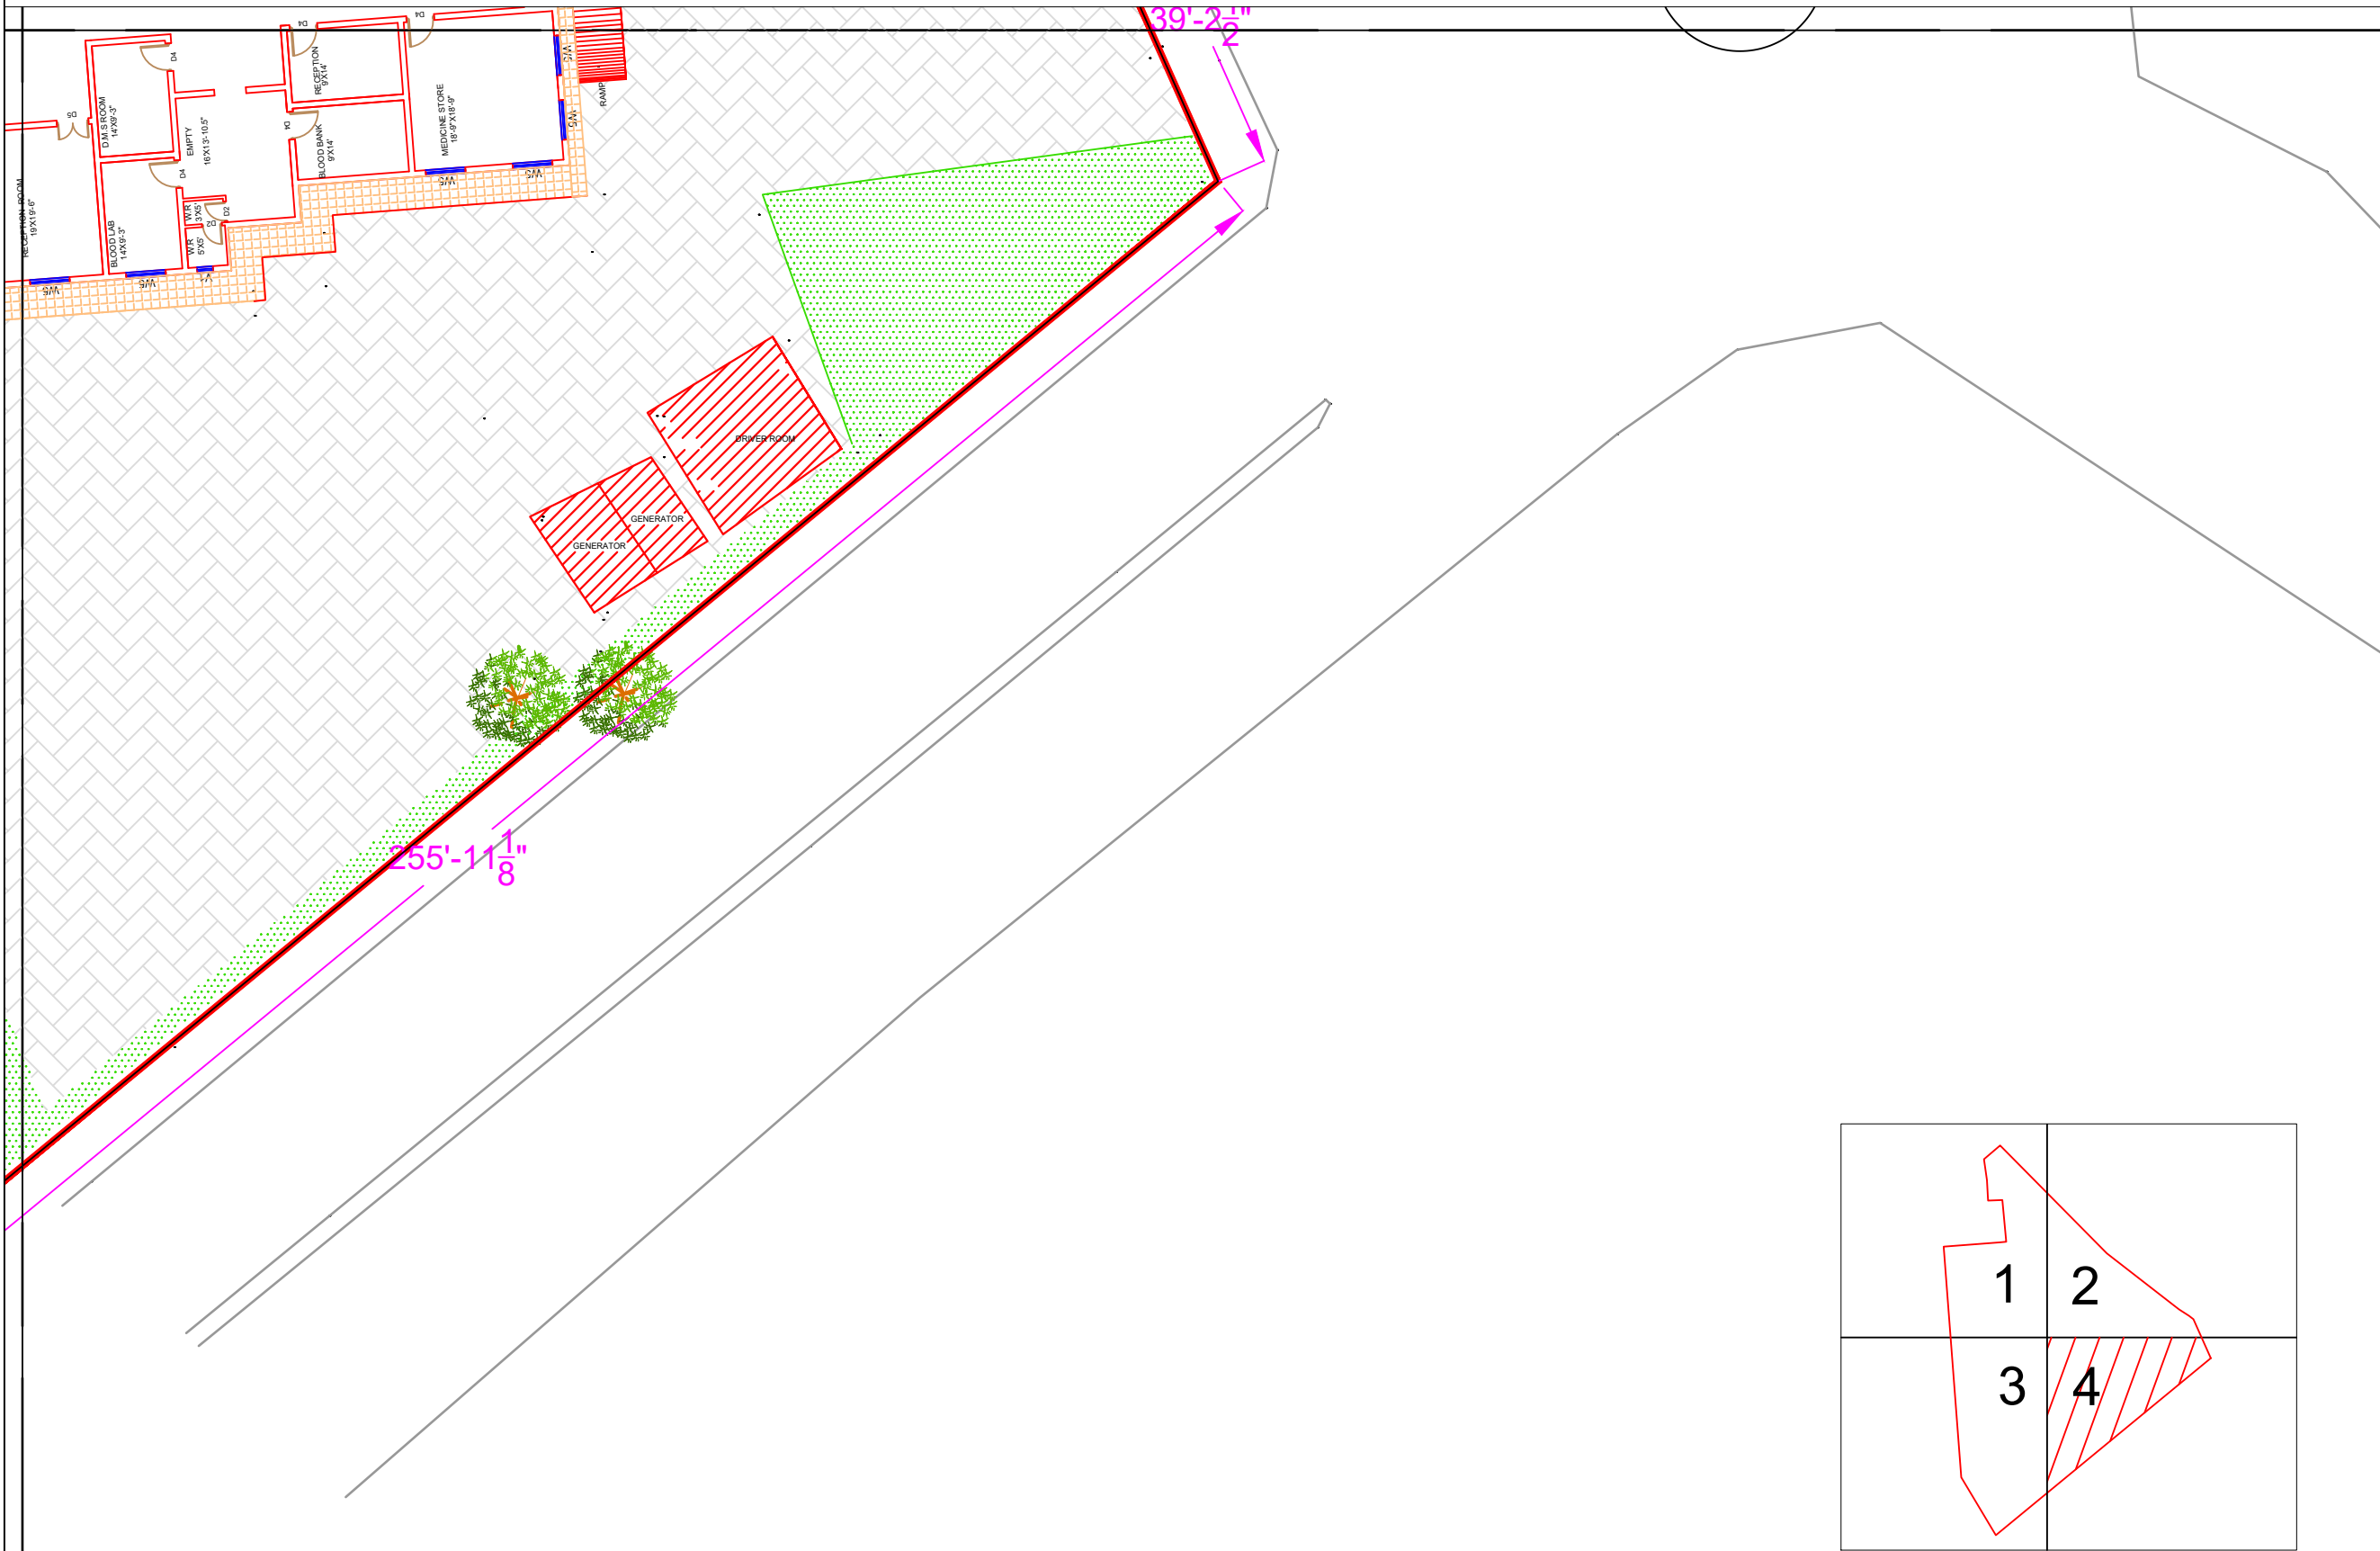

**Legends:**

|                           |  |
|---------------------------|--|
| Residential Area          |  |
| Road                      |  |
| Wall                      |  |
| Power Line                |  |
| OHT                       |  |
| Tree                      |  |
| Man Hole                  |  |
| Tube Well                 |  |
| Light Pole                |  |
| Lawns                     |  |
| Earthen Areas             |  |
| Asphalts Roads            |  |
| Tough Pavers              |  |
| P.C.C / Plinth Protection |  |
| Boundary Wall             |  |
| Brick Pavers / Soling     |  |
| Drain                     |  |
| Tap                       |  |
| Hand Pump                 |  |
| Air Conditioner           |  |
| Tube Light                |  |
| Fan                       |  |
| Roof Light                |  |
| Bulb                      |  |

| AREA                      |               |
|---------------------------|---------------|
| AREA WITHIN BOUNDARY WALL | 46104.476 Sft |
| AREA OF CLINICAL BLOCK    | 18545.614 Sft |
| PLINTH AREA OF BLOCK      | 14944.413 Sft |

| OPENING SCHEDULE OF DOORS AND WINDOWS |       |        |         |       |        |
|---------------------------------------|-------|--------|---------|-------|--------|
| DOORS                                 | WIDTH | HEIGHT | WINDOWS | WIDTH | HEIGHT |
| D1                                    | 2'-0" | 7'-0"  | W1      | 3'-0" | 5'-0"  |
| D2                                    | 2'-6" | 7'-0"  | W2      | 4'-0" | 4'-0"  |
| D3                                    | 3'-0" | 7'-0"  | W3      | 6'-0" | 6'-0"  |
| D4                                    | 3'-6" | 7'-0"  | W4      | 8'-0" | 8'-0"  |
| D5                                    | 4'-0" | 7'-0"  | W5      | 5'-0" | 5'-0"  |
| D6                                    | 4'-6" | 7'-0"  | W6      |       |        |
| D7                                    | 5'-0" | 7'-0"  | W7      |       |        |
| D8                                    | 6'-0" | 7'-0"  | V1      | 2'-0" | 2'-0"  |
| D9                                    | 7'-0" | 7'-0"  | V2      |       |        |

Project:

**CAD MAPPING OF TEHSIL HEAD QUARTER HOSPITALS, PUNJAB**

|                                                                              |                                                                                     |
|------------------------------------------------------------------------------|-------------------------------------------------------------------------------------|
| Client:                                                                      | Consultant:                                                                         |
| <br>GOVERNMENT OF THE PUNJAB<br>PRIMARY & SECONDARY<br>HEALTHCARE DEPARTMENT | <br>SKAFS CONSULTANT (Pvt.)<br>Limited<br>ENGINEERING AND ENVIRONMENT<br>CONSULTANT |

Drawing Title:

**THQ CIVIL HOSPITAL MULTAN  
HOSPITAL MASTER PLAN PART 4**


Drawing No.

**SKAFS/CIVIL-H-MULTAN/07**

# CLINICAL BLOCK OF THQ HOSPITAL CIVIL HOSPITAL MULTAN

## GROUND FLOOR

PART 1

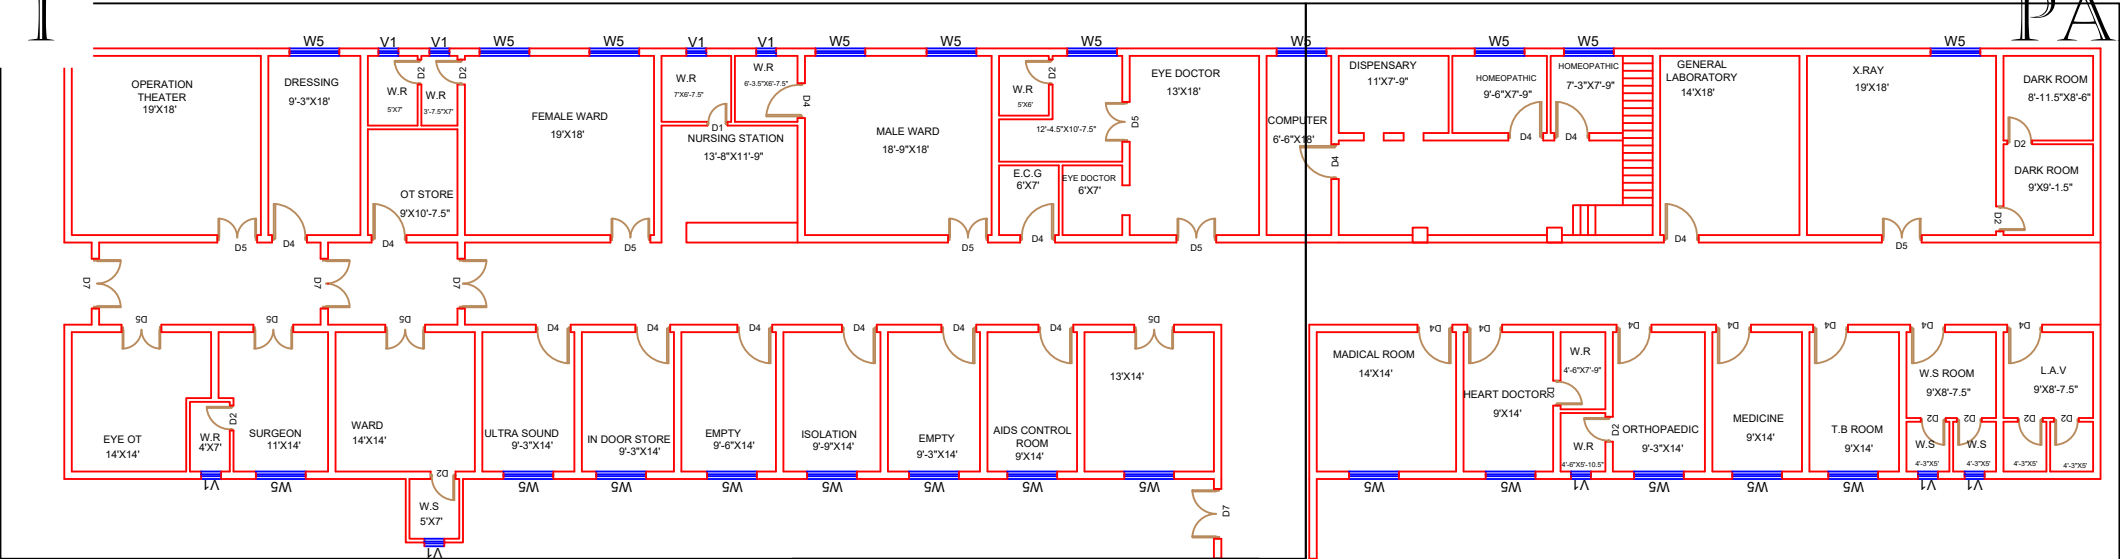

PART 3

PART 4

### Legends:

|                           |  |
|---------------------------|--|
| Residential Area          |  |
| Road                      |  |
| Wall                      |  |
| Power Line                |  |
| OHT                       |  |
| Tree                      |  |
| Man Hole                  |  |
| Tube Well                 |  |
| Light Pole                |  |
| Lawns                     |  |
| Earthen Areas             |  |
| Asphalts Roads            |  |
| Tough Pavers              |  |
| P.C.C / Plinth Protection |  |
| Boundary Wall             |  |
| Brick Pavers / Soling     |  |
| Drain                     |  |
| Tap                       |  |
| Hand Pump                 |  |
| Air Conditioner           |  |
| Tube Light                |  |
| Fan                       |  |
| Roof Light                |  |
| Bulb                      |  |

| AREA                      |  |  |               |  |  |
|---------------------------|--|--|---------------|--|--|
| AREA WITHIN BOUNDARY WALL |  |  | 46104.476 Sft |  |  |
| AREA OF CLINICAL BLOCK    |  |  | 18545.614 Sft |  |  |
| PLINTH AREA OF BLOCK      |  |  | 14944.413 Sft |  |  |

| OPENING SCHEDULE OF DOORS AND WINDOWS |       |        |         |       |        |
|---------------------------------------|-------|--------|---------|-------|--------|
| DOORS                                 | WIDTH | HEIGHT | WINDOWS | WIDTH | HEIGHT |
| D1                                    | 2'-0" | 7'-0"  | W1      | 3'-0" | 5'-0"  |
| D2                                    | 2'-6" | 7'-0"  | W2      | 4'-0" | 4'-0"  |
| D3                                    | 3'-0" | 7'-0"  | W3      | 6'-0" | 6'-0"  |
| D4                                    | 3'-6" | 7'-0"  | W4      | 8'-0" | 8'-0"  |
| D5                                    | 4'-0" | 7'-0"  | W5      | 5'-0" | 5'-0"  |
| D6                                    | 4'-6" | 7'-0"  | W6      |       |        |
| D7                                    | 5'-0" | 7'-0"  | W7      |       |        |
| D8                                    | 6'-0" | 7'-0"  | V1      | 2'-0" | 2'-0"  |
| D9                                    | 7'-0" | 7'-0"  | V2      |       |        |

Project:

**CAD MAPPING OF TEHSIL  
HEAD QUARTER HOSPITALS,  
PUNJAB**

Client:



GOVERNMENT OF THE PUNJAB  
PRIMARY & SECONDARY  
HEALTHCARE DEPARTMENT

Consultant:



SKAFS CONSULTANT (Pvt.)  
Limited  
ENGINEERING AND ENVIRONMENT  
CONSULTANT

Drawing Title:


**THQ CIVIL HOSPITAL MULTAN  
HOSPITAL CLINICAL BLOCK PLAN**

Drawing No.

**SKAFS/CIVIL-H-MULTAN/08**

# CLINICAL BLOCK OF THQ HOSPITAL CIVIL HOSPITAL MULTAN

## GROUND FLOOR PART 1

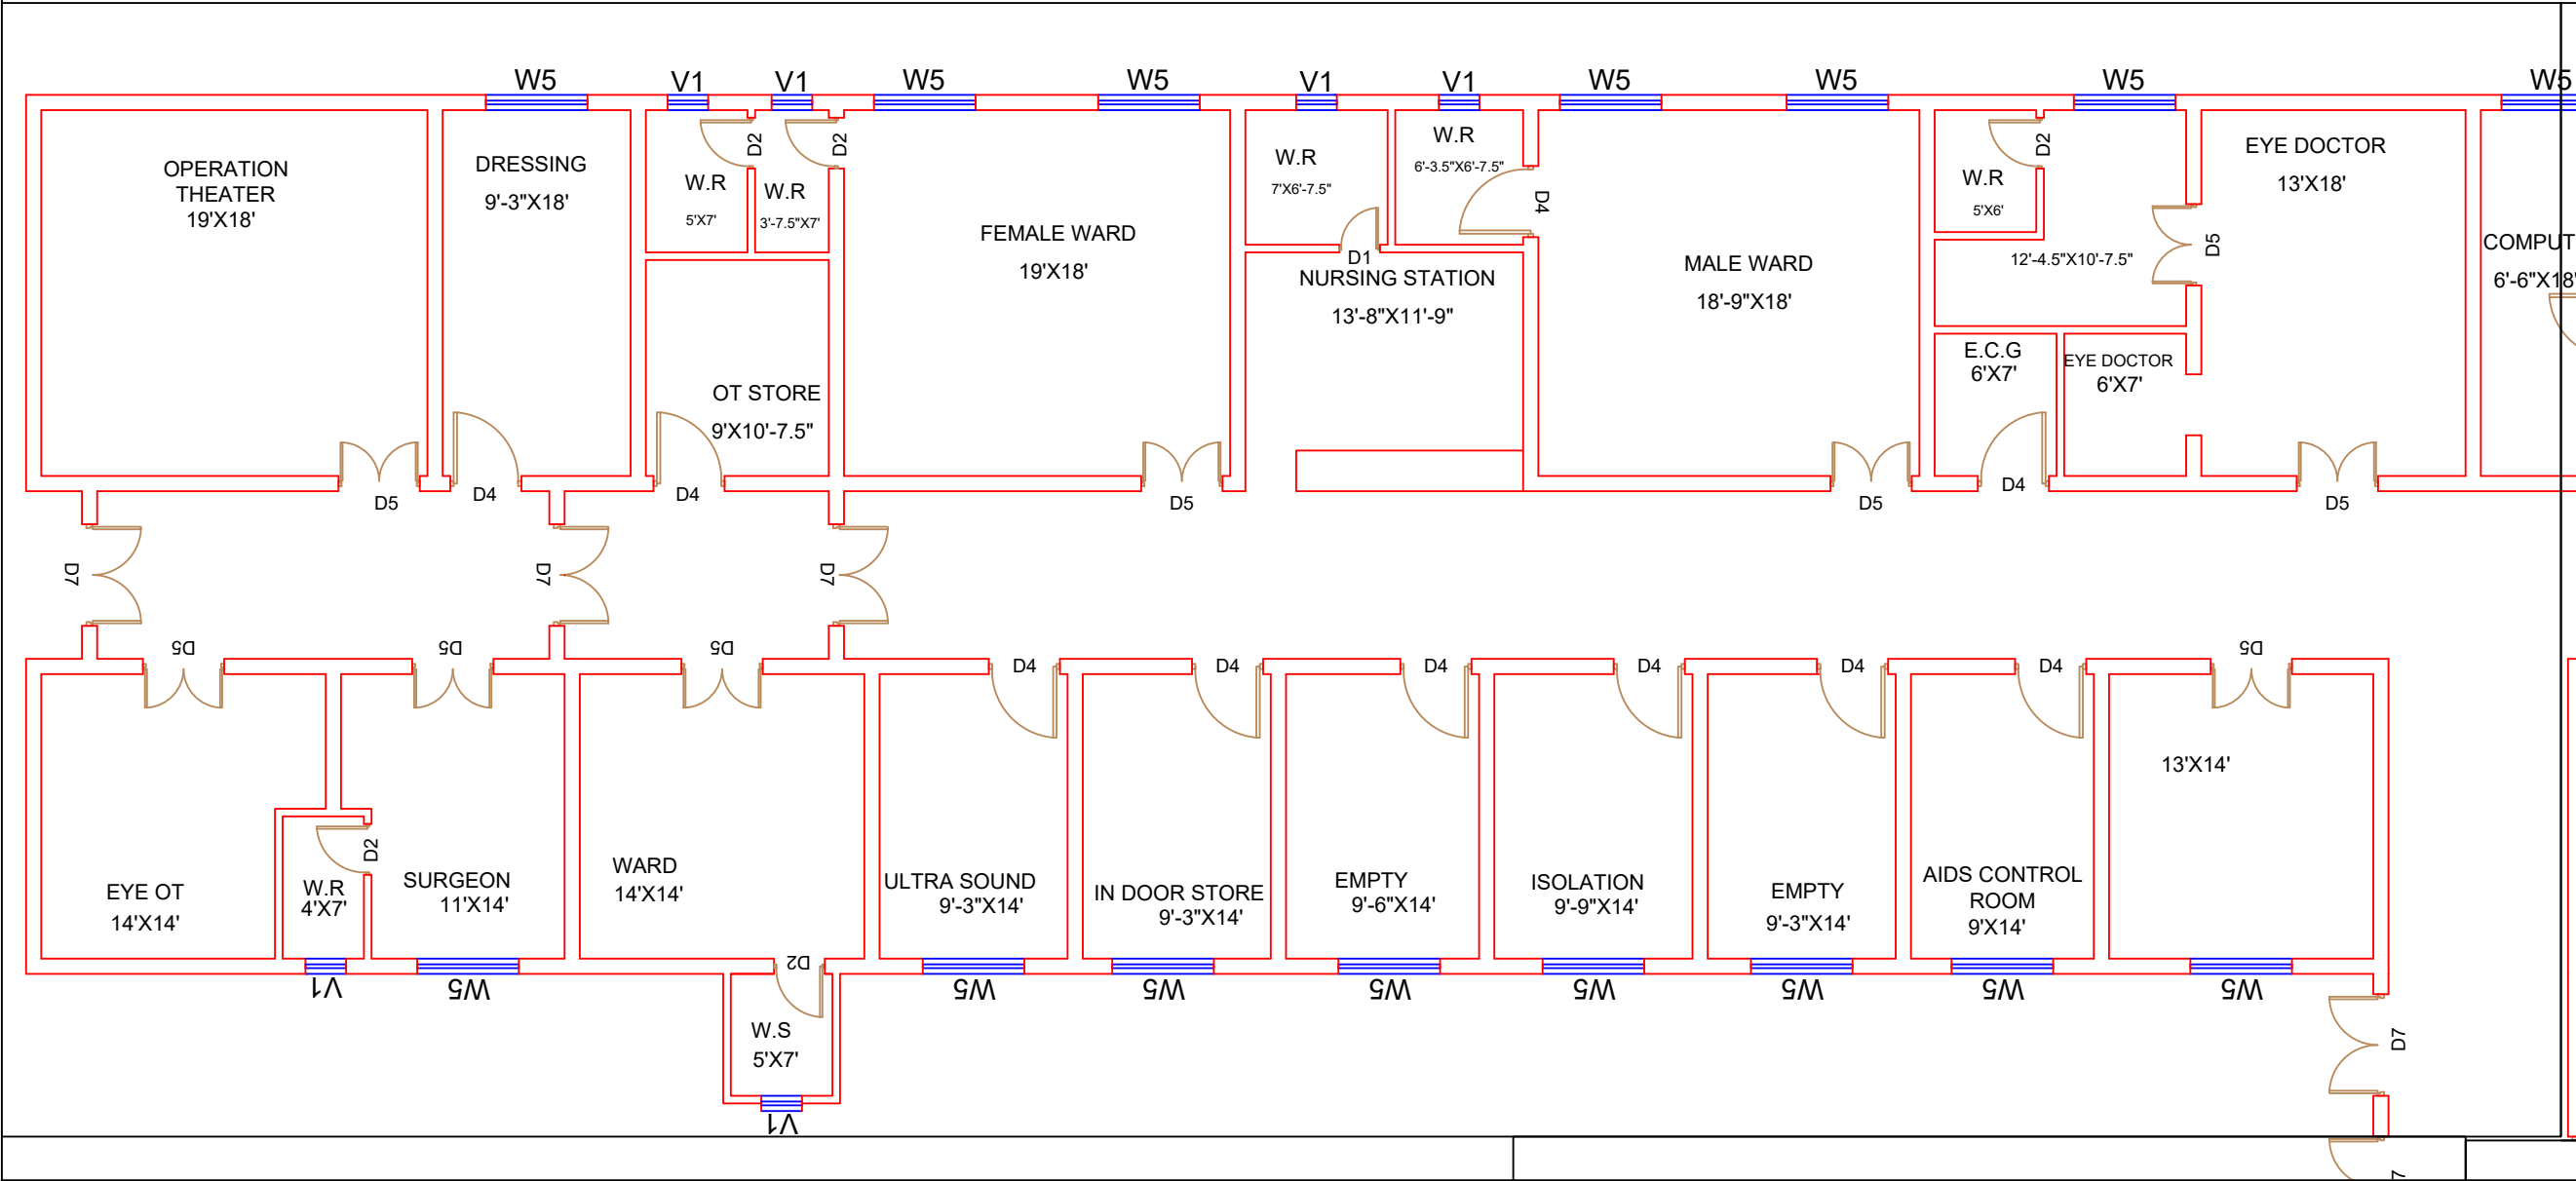

**Legends:**

|                           |  |
|---------------------------|--|
| Residential Area          |  |
| Road                      |  |
| Wall                      |  |
| Power Line                |  |
| OHT                       |  |
| Tree                      |  |
| Man Hole                  |  |
| Tube Well                 |  |
| Light Pole                |  |
| Lawns                     |  |
| Earthen Areas             |  |
| Asphalts Roads            |  |
| Tough Pavers              |  |
| P.C.C / Plinth Protection |  |
| Boundary Wall             |  |
| Brick Pavers / Soling     |  |
| Drain                     |  |
| Tap                       |  |
| Hand Pump                 |  |
| Air Conditioner           |  |
| Tube Light                |  |
| Fan                       |  |
| Roof Light                |  |
| Bulb                      |  |

| AREA                      |               |
|---------------------------|---------------|
| AREA WITHIN BOUNDARY WALL | 46104.476 Sft |
| AREA OF CLINICAL BLOCK    | 18545.614 Sft |
| PLINTH AREA OF BLOCK      | 14944.413 Sft |

| OPENING SCHEDULE OF DOORS AND WINDOWS |       |        |         |       |        |
|---------------------------------------|-------|--------|---------|-------|--------|
| DOORS                                 | WIDTH | HEIGHT | WINDOWS | WIDTH | HEIGHT |
| D1                                    | 2'-0" | 7'-0"  | W1      | 3'-0" | 5'-0"  |
| D2                                    | 2'-6" | 7'-0"  | W2      | 4'-0" | 4'-0"  |
| D3                                    | 3'-0" | 7'-0"  | W3      | 6'-0" | 6'-0"  |
| D4                                    | 3'-6" | 7'-0"  | W4      | 8'-0" | 8'-0"  |
| D5                                    | 4'-0" | 7'-0"  | W5      | 5'-0" | 5'-0"  |
| D6                                    | 4'-6" | 7'-0"  | W6      |       |        |
| D7                                    | 5'-0" | 7'-0"  | W7      |       |        |
| D8                                    | 6'-0" | 7'-0"  | V1      | 2'-0" | 2'-0"  |
| D9                                    | 7'-0" | 7'-0"  | V2      |       |        |

Project:  
**CAD MAPPING OF TEHSIL HEAD QUARTER HOSPITALS, PUNJAB**

|                                                                                         |                                                                                                 |
|-----------------------------------------------------------------------------------------|-------------------------------------------------------------------------------------------------|
| Client:<br><br>GOVERNMENT OF THE PUNJAB<br>PRIMARY & SECONDARY<br>HEALTHCARE DEPARTMENT | Consultant:<br><br>SKAFS CONSULTANT (Pvt.) Limited<br>ENGINEERING AND ENVIRONMENT<br>CONSULTANT |
|-----------------------------------------------------------------------------------------|-------------------------------------------------------------------------------------------------|

Drawing Title:  
**THQ CIVIL HOSPITAL MULTAN  
CLINICAL BLOCK PLAN (PART 1)**

Drawing No.  
**SKAFS/CIVIL-H-MULTAN/09**

[illegible]

|                           |                                                                                       |
|---------------------------|---------------------------------------------------------------------------------------|
| Residential Area          |    |
| Road                      |    |
| Wall                      |    |
| Power Line                |    |
| OHT                       |    |
| Tree                      |    |
| Man Hole                  |    |
| Tube Well                 |    |
| Light Pole                |    |
| Lawns                     |    |
| Earthen Areas             |    |
| Asphalts Roads            |    |
| Tough Pavers              |    |
| P.C.C / Plinth Protection |    |
| Boundary Wall             |    |
| Brick Pavers / Soling     |    |
| Drain                     |    |
| Tap                       |    |
| Hand Pump                 |   |
| Air Conditioner           |  |
| Tube Light                |  |
| Fan                       |  |
| Roof Light                |  |
| Bulb                      |  |

| AREA                      |               |
|---------------------------|---------------|
| AREA WITHIN BOUNDARY WALL | 46104.476 Sft |
| AREA OF CLINICAL BLOCK    | 18545.614 Sft |
| PLINTH AREA OF BLOCK      | 14944.413 Sft |

| OPENING SCHEDULE OF DOORS AND WINDOWS |       |        |         |       |        |
|---------------------------------------|-------|--------|---------|-------|--------|
| DOORS                                 | WIDTH | HEIGHT | WINDOWS | WIDTH | HEIGHT |
| D1                                    | 2'-0" | 7'-0"  | W1      | 3'-0" | 5'-0"  |
| D2                                    | 2'-6" | 7'-0"  | W2      | 4'-0" | 4'-0"  |
| D3                                    | 3'-0" | 7'-0"  | W3      | 6'-0" | 6'-0"  |
| D4                                    | 3'-6" | 7'-0"  | W4      | 8'-0" | 8'-0"  |
| D5                                    | 4'-0" | 7'-0"  | W5      | 5'-0" | 5'-0"  |
| D6                                    | 4'-6" | 7'-0"  | W6      |       |        |
| D7                                    | 5'-0" | 7'-0"  | W7      |       |        |
| D8                                    | 6'-0" | 7'-0"  | V1      | 2'-0" | 2'-0"  |
| D9                                    | 7'-0" | 7'-0"  | V2      |       |        |

Project:  
**CAD MAPPING OF TEHSIL  
HEAD QUARTER HOSPITALS,  
PUNJAB**


|                                                                                                                                                                                                          |                                                                                                                                                                                                                  |
|----------------------------------------------------------------------------------------------------------------------------------------------------------------------------------------------------------|------------------------------------------------------------------------------------------------------------------------------------------------------------------------------------------------------------------|
| <p><b>Client:</b></p>  <p>GOVERNMENT OF THE PUNJAB<br/><b>PRIMARY &amp; SECONDARY<br/>HEALTHCARE DEPARTMENT</b></p> | <p><b>Consultant:</b></p>  <p><b>SKAFS CONSULTANT (Pvt.)<br/>Limited</b><br/>ENGINEERING AND ENVIRONMENT<br/>CONSULTANT</p> |
|----------------------------------------------------------------------------------------------------------------------------------------------------------------------------------------------------------|------------------------------------------------------------------------------------------------------------------------------------------------------------------------------------------------------------------|

Drawing Title:  
**THQ CIVIL HOSPITAL MULTAN  
CLINICAL BLOCK PLAN (PART 2)**

Drawing No. **SKAFS/CIVIL-H-MULTAN /10**

# CLINICAL BLOCK OF THQ HOSPITAL CIVIL HOSPITAL MULTAN

## GROUND FLOOR PART 3

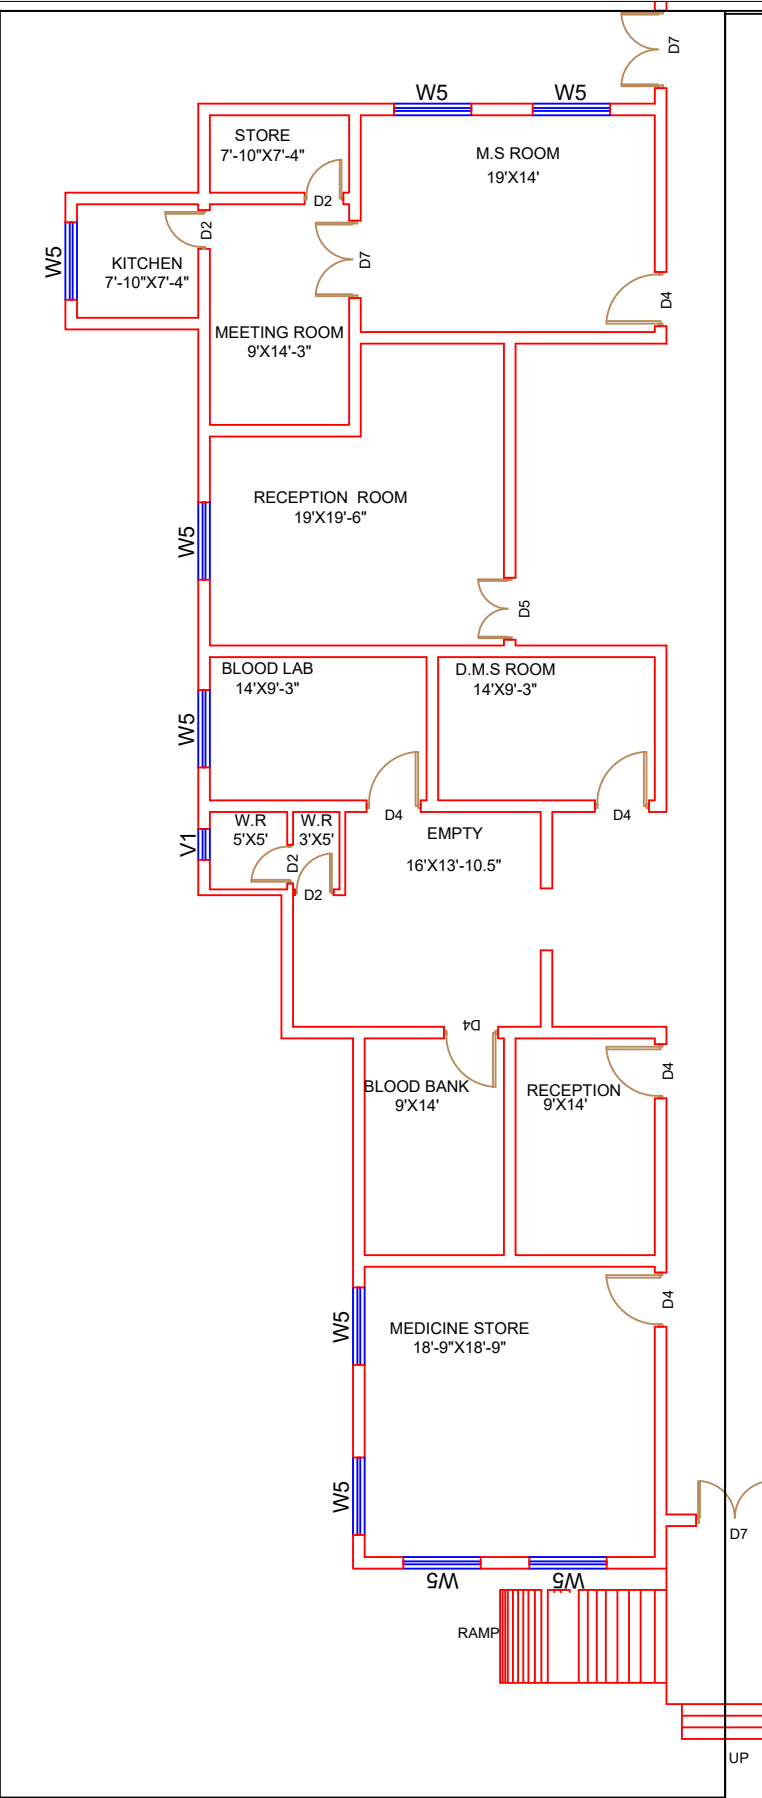

**Legends:**

|                           |  |
|---------------------------|--|
| Residential Area          |  |
| Road                      |  |
| Wall                      |  |
| Power Line                |  |
| OHT                       |  |
| Tree                      |  |
| Man Hole                  |  |
| Tube Well                 |  |
| Light Pole                |  |
| Lawns                     |  |
| Earthen Areas             |  |
| Asphalts Roads            |  |
| Tough Pavers              |  |
| P.C.C / Plinth Protection |  |
| Boundary Wall             |  |
| Brick Pavers / Soling     |  |
| Drain                     |  |
| Tap                       |  |
| Hand Pump                 |  |
| Air Conditioner           |  |
| Tube Light                |  |
| Fan                       |  |
| Roof Light                |  |
| Bulb                      |  |

| AREA                      |               |
|---------------------------|---------------|
| AREA WITHIN BOUNDARY WALL | 46104.476 Sft |
| AREA OF CLINICAL BLOCK    | 18545.614 Sft |
| PLINTH AREA OF BLOCK      | 14944.413 Sft |

| OPENING SCHEDULE OF DOORS AND WINDOWS |       |        |         |       |        |
|---------------------------------------|-------|--------|---------|-------|--------|
| DOORS                                 | WIDTH | HEIGHT | WINDOWS | WIDTH | HEIGHT |
| D1                                    | 2'-0" | 7'-0"  | W1      | 3'-0" | 5'-0"  |
| D2                                    | 2'-6" | 7'-0"  | W2      | 4'-0" | 4'-0"  |
| D3                                    | 3'-0" | 7'-0"  | W3      | 6'-0" | 6'-0"  |
| D4                                    | 3'-6" | 7'-0"  | W4      | 8'-0" | 8'-0"  |
| D5                                    | 4'-0" | 7'-0"  | W5      | 5'-0" | 5'-0"  |
| D6                                    | 4'-6" | 7'-0"  | W6      |       |        |
| D7                                    | 5'-0" | 7'-0"  | W7      |       |        |
| D8                                    | 6'-0" | 7'-0"  | V1      | 2'-0" | 2'-0"  |
| D9                                    | 7'-0" | 7'-0"  | V2      |       |        |

Project:

**CAD MAPPING OF TEHSIL HEAD QUARTER HOSPITALS, PUNJAB**

|                                                                              |                                                                                     |
|------------------------------------------------------------------------------|-------------------------------------------------------------------------------------|
| Client:                                                                      | Consultant:                                                                         |
| <br>GOVERNMENT OF THE PUNJAB<br>PRIMARY & SECONDARY<br>HEALTHCARE DEPARTMENT | <br>SKAFS CONSULTANT (Pvt.)<br>Limited<br>ENGINEERING AND ENVIRONMENT<br>CONSULTANT |

Drawing Title:


**THQ CIVIL HOSPITAL MULTAN  
CLINICAL BLOCK PLAN (PART 3)**

Drawing No.

**SKAFS/CIVIL-H-MULTAN/11**

# CLINICAL BLOCK OF THQ HOSPITAL CIVIL HOSPITAL MULTAN

## GROUND FLOOR PART 4

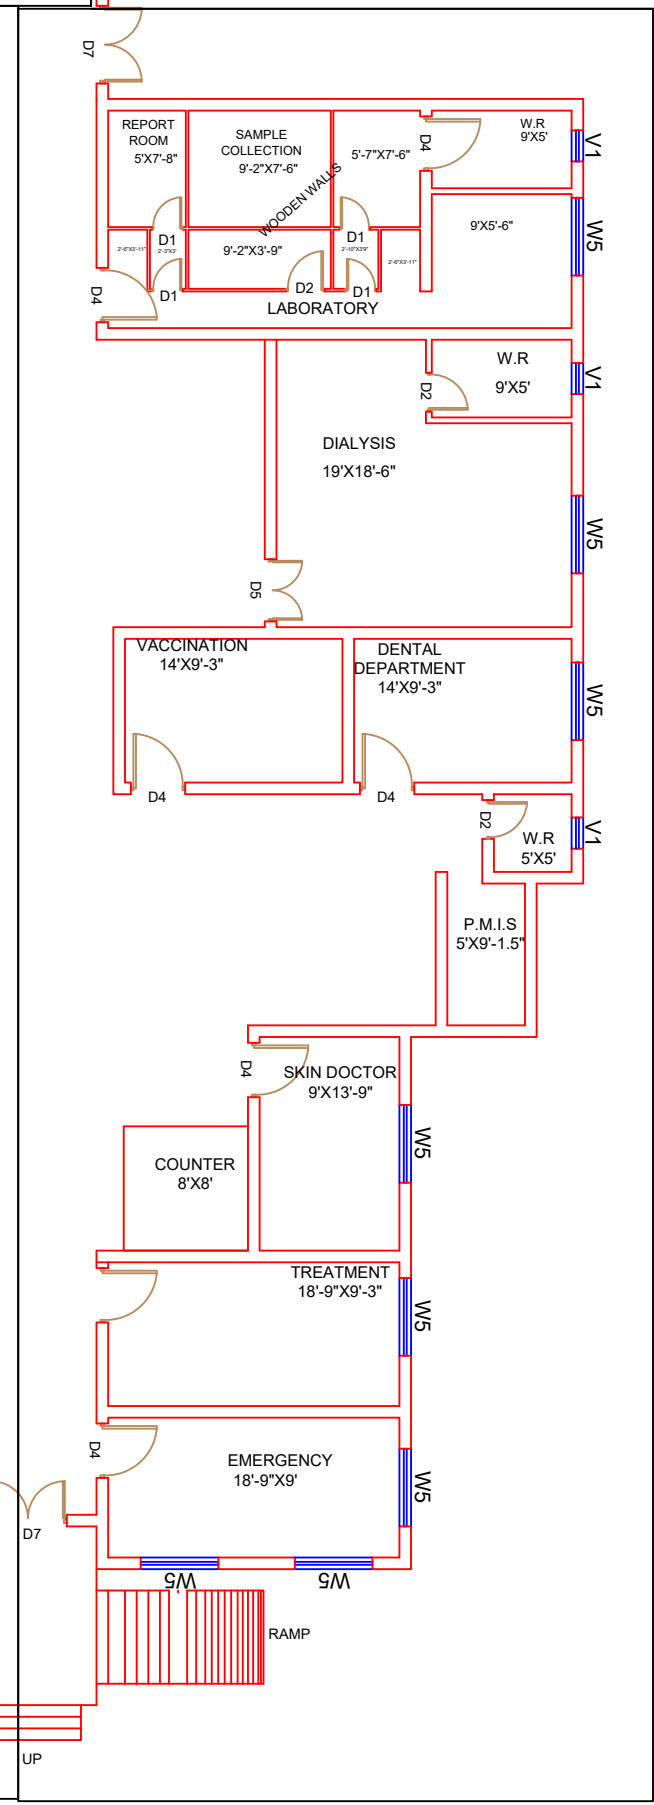

**Legends:**

|                           |  |
|---------------------------|--|
| Residential Area          |  |
| Road                      |  |
| Wall                      |  |
| Power Line                |  |
| OHT                       |  |
| Tree                      |  |
| Man Hole                  |  |
| Tube Well                 |  |
| Light Pole                |  |
| Lawns                     |  |
| Earthen Areas             |  |
| Asphalts Roads            |  |
| Tough Pavers              |  |
| P.C.C / Plinth Protection |  |
| Boundary Wall             |  |
| Brick Pavers / Soling     |  |
| Drain                     |  |
| Tap                       |  |
| Hand Pump                 |  |
| Air Conditioner           |  |
| Tube Light                |  |
| Fan                       |  |
| Roof Light                |  |
| Bulb                      |  |

| AREA                      |               |
|---------------------------|---------------|
| AREA WITHIN BOUNDARY WALL | 46104.476 Sft |
| AREA OF CLINICAL BLOCK    | 18545.614 Sft |
| PLINTH AREA OF BLOCK      | 14944.413 Sft |

| OPENING SCHEDULE OF DOORS AND WINDOWS |       |        |         |       |        |
|---------------------------------------|-------|--------|---------|-------|--------|
| DOORS                                 | WIDTH | HEIGHT | WINDOWS | WIDTH | HEIGHT |
| D1                                    | 2'-0" | 7'-0"  | W1      | 3'-0" | 5'-0"  |
| D2                                    | 2'-6" | 7'-0"  | W2      | 4'-0" | 4'-0"  |
| D3                                    | 3'-0" | 7'-0"  | W3      | 6'-0" | 6'-0"  |
| D4                                    | 3'-6" | 7'-0"  | W4      | 8'-0" | 8'-0"  |
| D5                                    | 4'-0" | 7'-0"  | W5      | 5'-0" | 5'-0"  |
| D6                                    | 4'-6" | 7'-0"  | W6      |       |        |
| D7                                    | 5'-0" | 7'-0"  | W7      |       |        |
| D8                                    | 6'-0" | 7'-0"  | V1      | 2'-0" | 2'-0"  |
| D9                                    | 7'-0" | 7'-0"  | V2      |       |        |

Project:

**CAD MAPPING OF TEHSIL HEAD QUARTER HOSPITALS, PUNJAB**

|                                                                              |                                                                                     |
|------------------------------------------------------------------------------|-------------------------------------------------------------------------------------|
| Client:                                                                      | Consultant:                                                                         |
| <br>GOVERNMENT OF THE PUNJAB<br>PRIMARY & SECONDARY<br>HEALTHCARE DEPARTMENT | <br>SKAFS CONSULTANT (Pvt.)<br>Limited<br>ENGINEERING AND ENVIRONMENT<br>CONSULTANT |

Drawing Title:


**THQ CIVIL HOSPITAL MULTAN  
CLINICAL BLOCK PLAN (PART 4)**

Drawing No.

**SKAFS/CIVIL-H-MULTAN/12**

# CLINICAL BLOCK OF THQ HOSPITAL CIVIL HOSPITAL MULTAN

## FIRST FLOOR PART 1

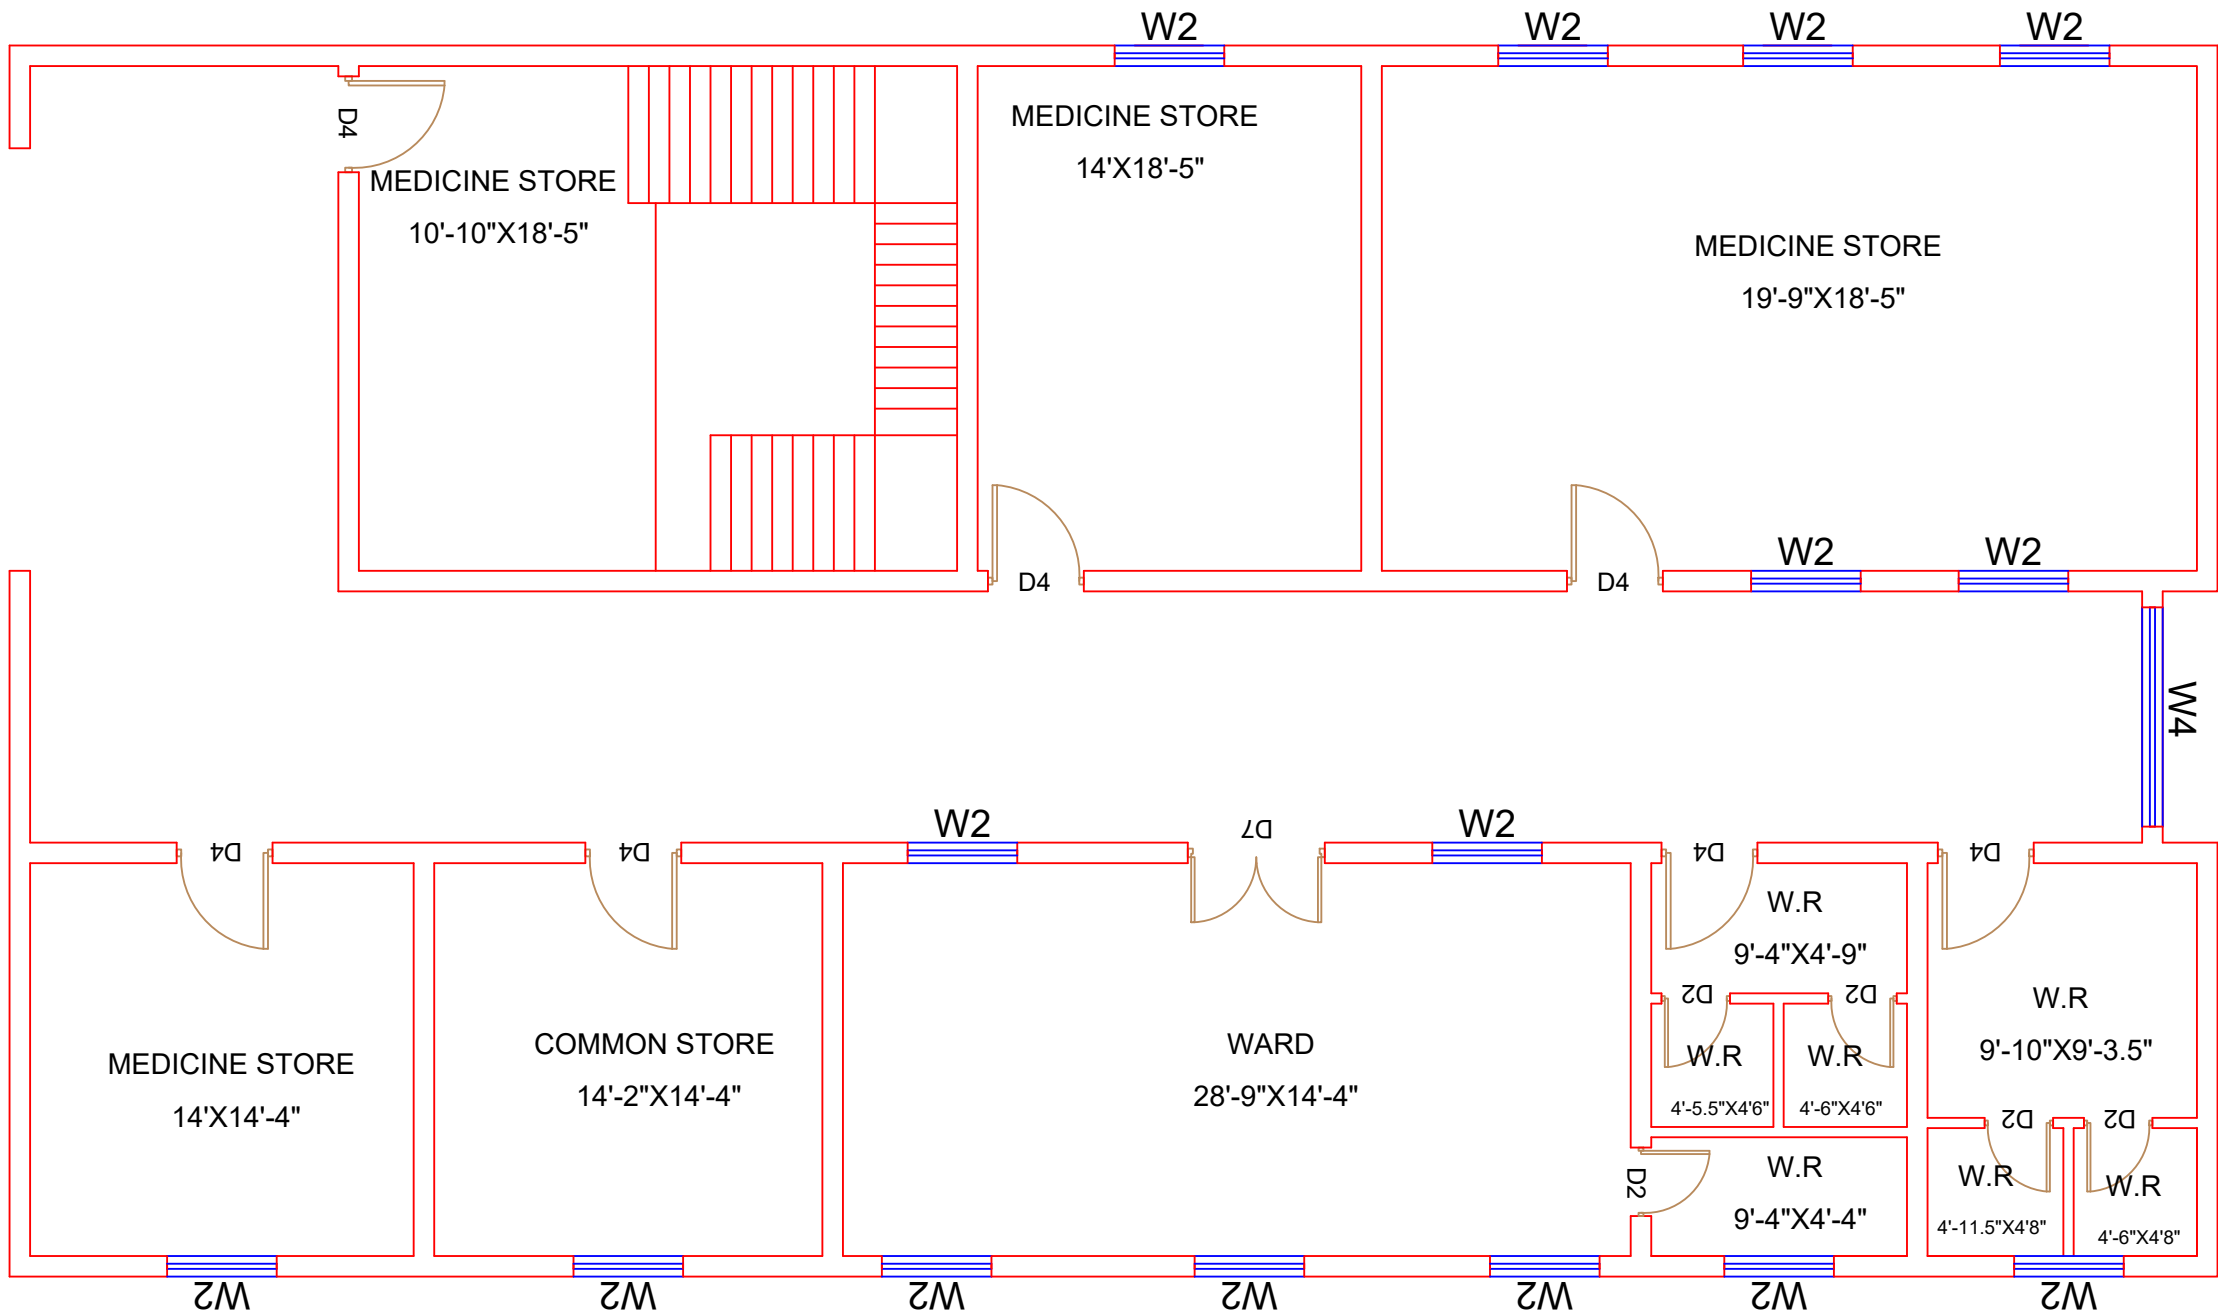

**Legends:**

|                           |  |
|---------------------------|--|
| Residential Area          |  |
| Road                      |  |
| Wall                      |  |
| Power Line                |  |
| OHT                       |  |
| Tree                      |  |
| Man Hole                  |  |
| Tube Well                 |  |
| Light Pole                |  |
| Lawns                     |  |
| Earthen Areas             |  |
| Asphalts Roads            |  |
| Tough Pavers              |  |
| P.C.C / Plinth Protection |  |
| Boundary Wall             |  |
| Brick Pavers / Soling     |  |
| Drain                     |  |
| Tap                       |  |
| Hand Pump                 |  |
| Air Conditioner           |  |
| Tube Light                |  |
| Fan                       |  |
| Roof Light                |  |
| Bulb                      |  |

| AREA                      |               |
|---------------------------|---------------|
| AREA WITHIN BOUNDARY WALL | 46104.476 Sft |
| AREA OF CLINICAL BLOCK    | 18545.614 Sft |
| PLINTH AREA OF BLOCK      | 14944.413 Sft |

| OPENING SCHEDULE OF DOORS AND WINDOWS |       |        |         |       |        |
|---------------------------------------|-------|--------|---------|-------|--------|
| DOORS                                 | WIDTH | HEIGHT | WINDOWS | WIDTH | HEIGHT |
| D1                                    | 2'-0" | 7'-0"  | W1      | 3'-0" | 5'-0"  |
| D2                                    | 2'-6" | 7'-0"  | W2      | 4'-0" | 4'-0"  |
| D3                                    | 3'-0" | 7'-0"  | W3      | 6'-0" | 6'-0"  |
| D4                                    | 3'-6" | 7'-0"  | W4      | 8'-0" | 8'-0"  |
| D5                                    | 4'-0" | 7'-0"  | W5      | 5'-0" | 5'-0"  |
| D6                                    | 4'-6" | 7'-0"  | W6      |       |        |
| D7                                    | 5'-0" | 7'-0"  | W7      |       |        |
| D8                                    | 6'-0" | 7'-0"  | V1      | 2'-0" | 2'-0"  |
| D9                                    | 7'-0" | 7'-0"  | V2      |       |        |


Project:  
**CAD MAPPING OF TEHSIL  
HEAD QUARTER HOSPITALS,  
PUNJAB**

|                                                                                         |                                                                                                    |
|-----------------------------------------------------------------------------------------|----------------------------------------------------------------------------------------------------|
| Client:<br><br>GOVERNMENT OF THE PUNJAB<br>PRIMARY & SECONDARY<br>HEALTHCARE DEPARTMENT | Consultant:<br><br>SKAFS CONSULTANT (Pvt.)<br>Limited<br>ENGINEERING AND ENVIRONMENT<br>CONSULTANT |
|-----------------------------------------------------------------------------------------|----------------------------------------------------------------------------------------------------|

Drawing Title:  
**THQ CIVIL HOSPITAL MULTAN  
FIRST FLOOR PLAN (PART 1)**

Drawing No.  
**SKAFS/CIVIL-H-MULTAN/13**

# ELECTRICAL LAYOUT PLAN OF THQ HOSPITAL CIVIL HOSPITAL MULTAN GROUND FLOOR

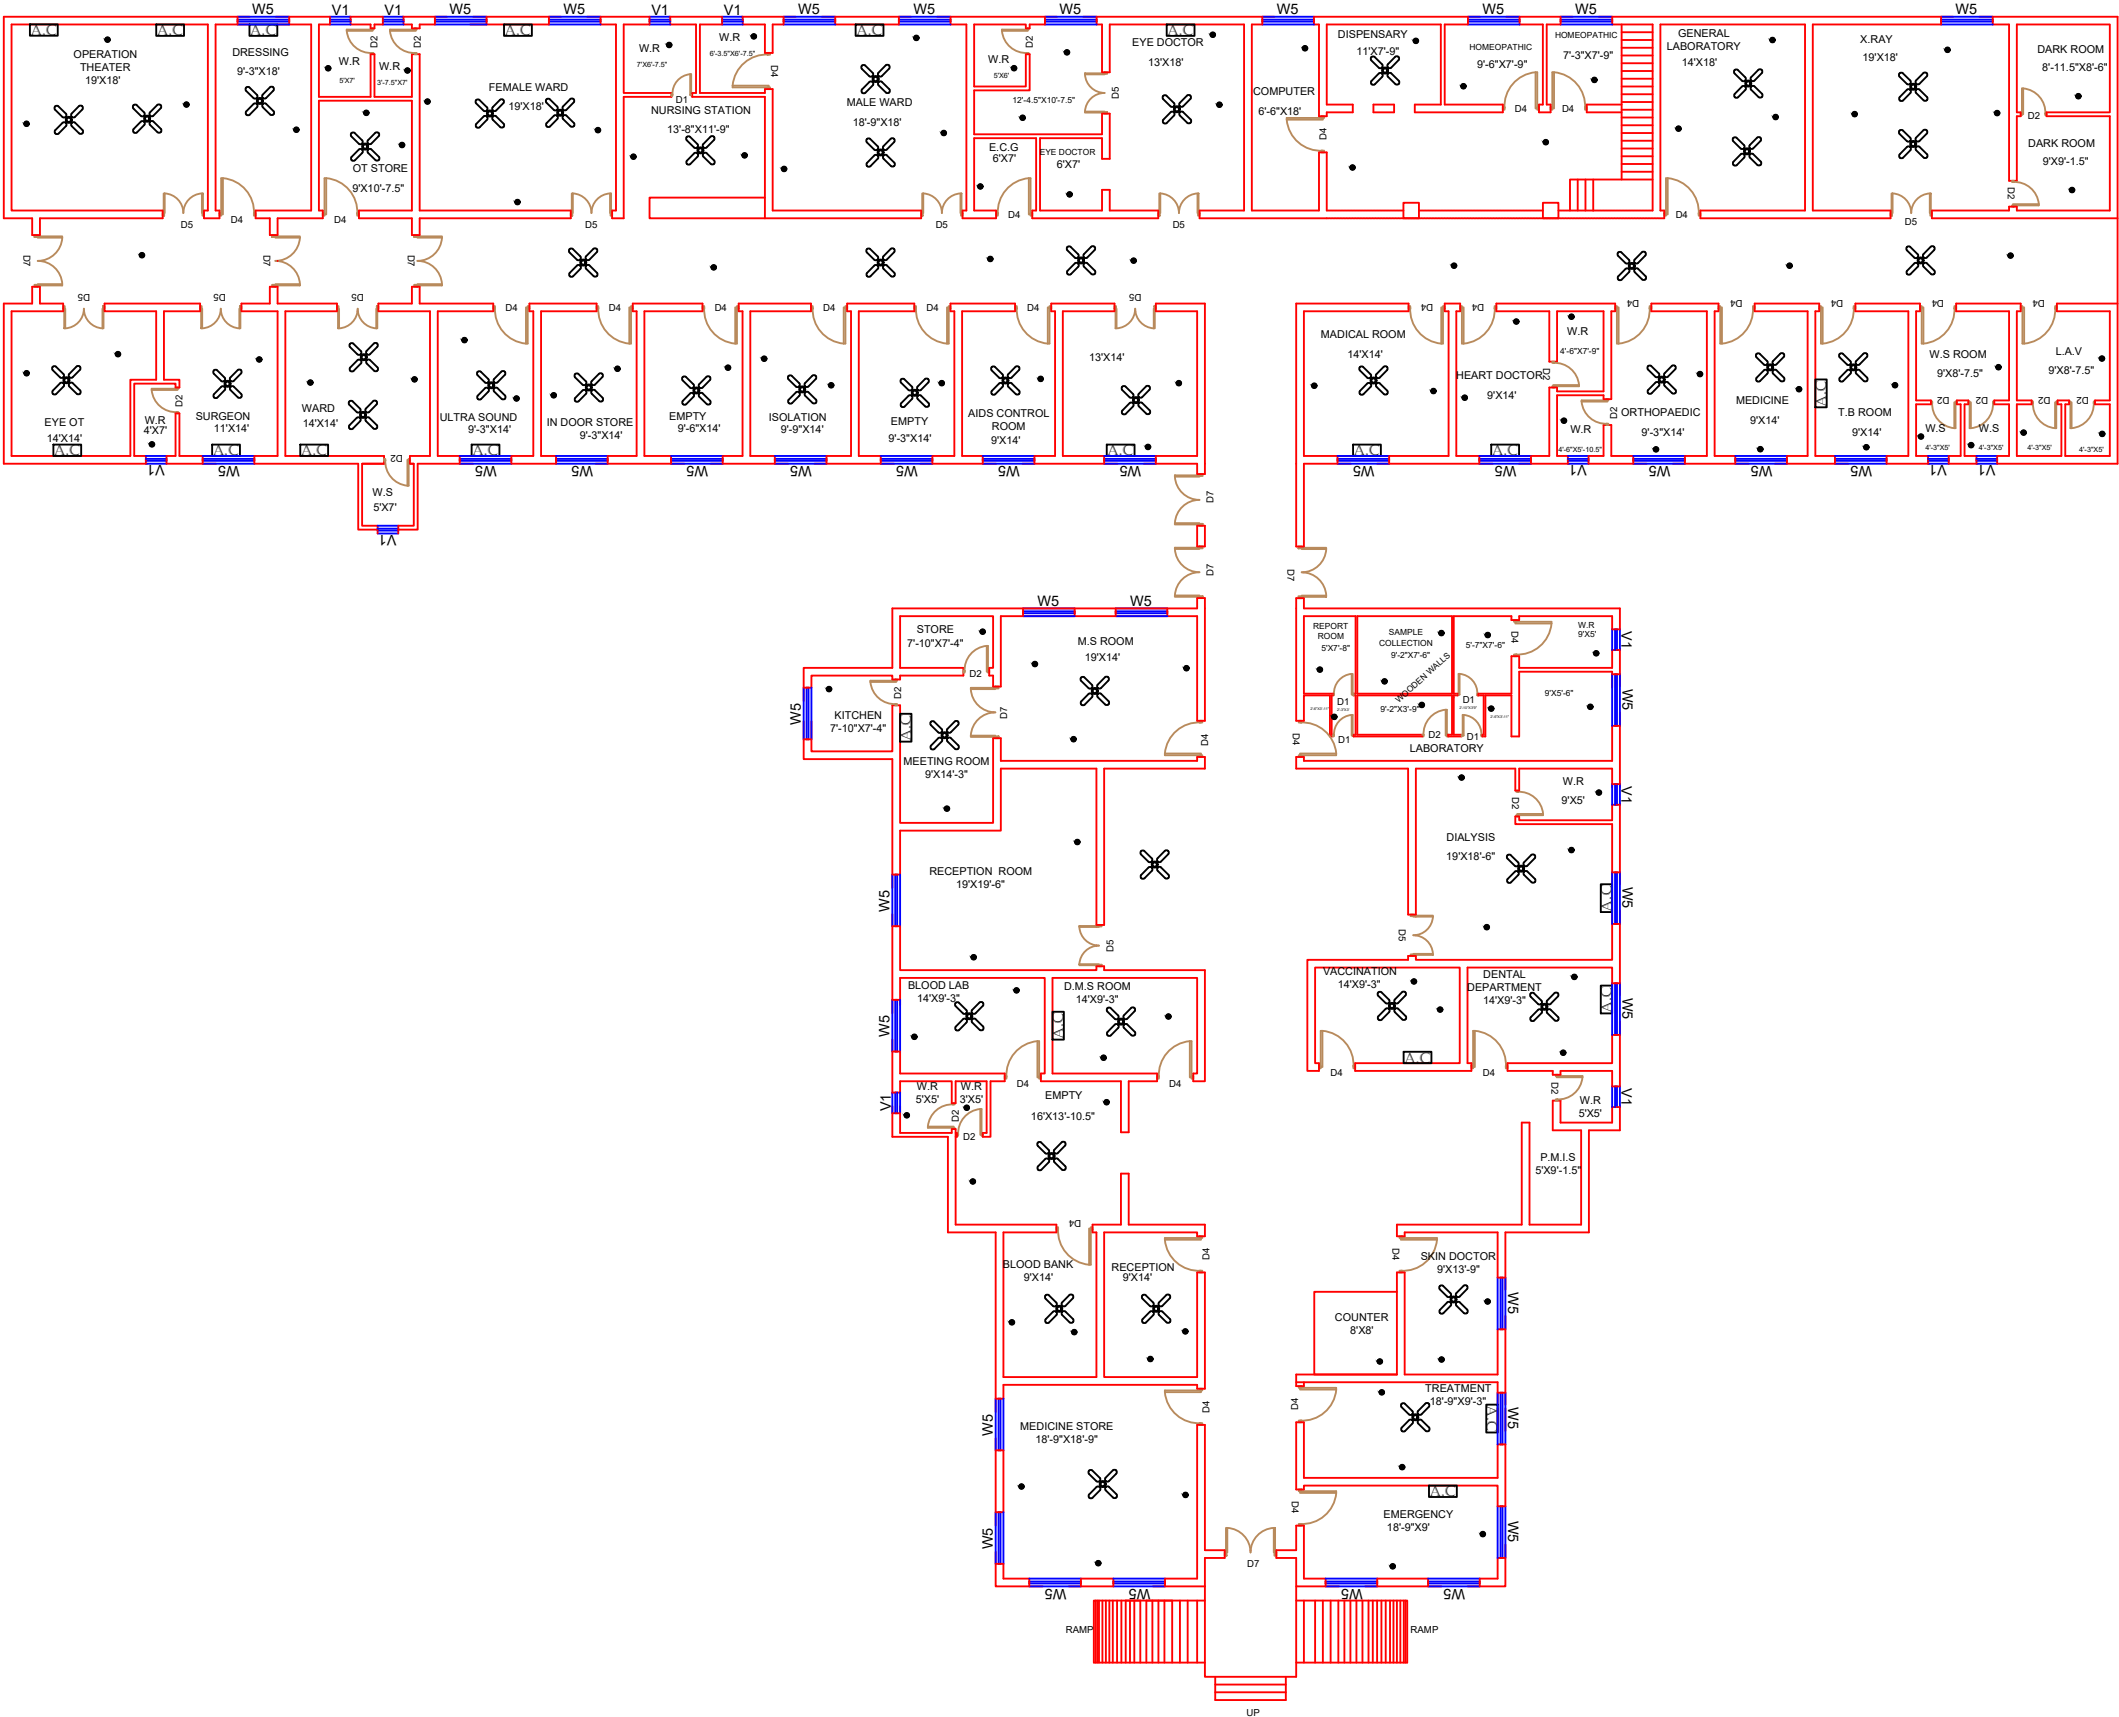

**Legends:**

Residential Area

Road

Wall

Power Line

OHT

Tree

Man Hole

Tube Well

Light Pole

Lawns

Earthen Areas

Asphalts Roads

Tough Pavers

P.C.C / Plinth Protection

Boundary Wall

Brick Pavers / Soling

Drain

Tap

Hand Pump

Air Conditioner

Tube Light

Fan

Roof Light

Bulb

AREA

AREA WITHIN BOUNDARY WALL

46104.476 Sft

AREA OF CLINICAL BLOCK

18545.614 Sft

PLINTH AREA OF BLOCK

14944.413 Sft

OPENING SCHEDULE OF DOORS AND WINDOWS

| DOORS | WIDTH | HEIGHT | WINDOWS | WIDTH | HEIGHT |
|-------|-------|--------|---------|-------|--------|
| D1    | 2'-0" | 7'-0"  | W1      | 3'-0" | 5'-0"  |
| D2    | 2'-6" | 7'-0"  | W2      | 4'-0" | 4'-0"  |
| D3    | 3'-0" | 7'-0"  | W3      | 6'-0" | 6'-0"  |
| D4    | 3'-6" | 7'-0"  | W4      | 8'-0" | 8'-0"  |
| D5    | 4'-0" | 7'-0"  | W5      | 5'-0" | 5'-0"  |
| D6    | 4'-6" | 7'-0"  | W6      |       |        |
| D7    | 5'-0" | 7'-0"  | W7      |       |        |
| D8    | 6'-0" | 7'-0"  | V1      | 2'-0" | 2'-0"  |
| D9    | 7'-0" | 7'-0"  | V2      |       |        |

Project:

CAD MAPPING OF TEHSIL  
HEAD QUARTER HOSPITALS,  
PUNJAB

Client:

GOVERNMENT OF THE PUNJAB  
PRIMARY & SECONDARY  
HEALTHCARE DEPARTMENT

Consultant:

SKAFS CONSULTANT (Pvt.)  
Limited  
ENGINEERING AND ENVIRONMENT  
CONSULTANT

Drawing Title:


THQ CIVIL HOSPITAL MULTAN  
ELECTRICAL PLAN (GROUND FLOOR)

Drawing No.

SKAFS/CIVIL-H-MULTAN/14

# ELECTRICAL LAYOUT PLAN OF THQ HOSPITAL

## CIVIL HOSPITAL MULTAN FIRST FLOOR

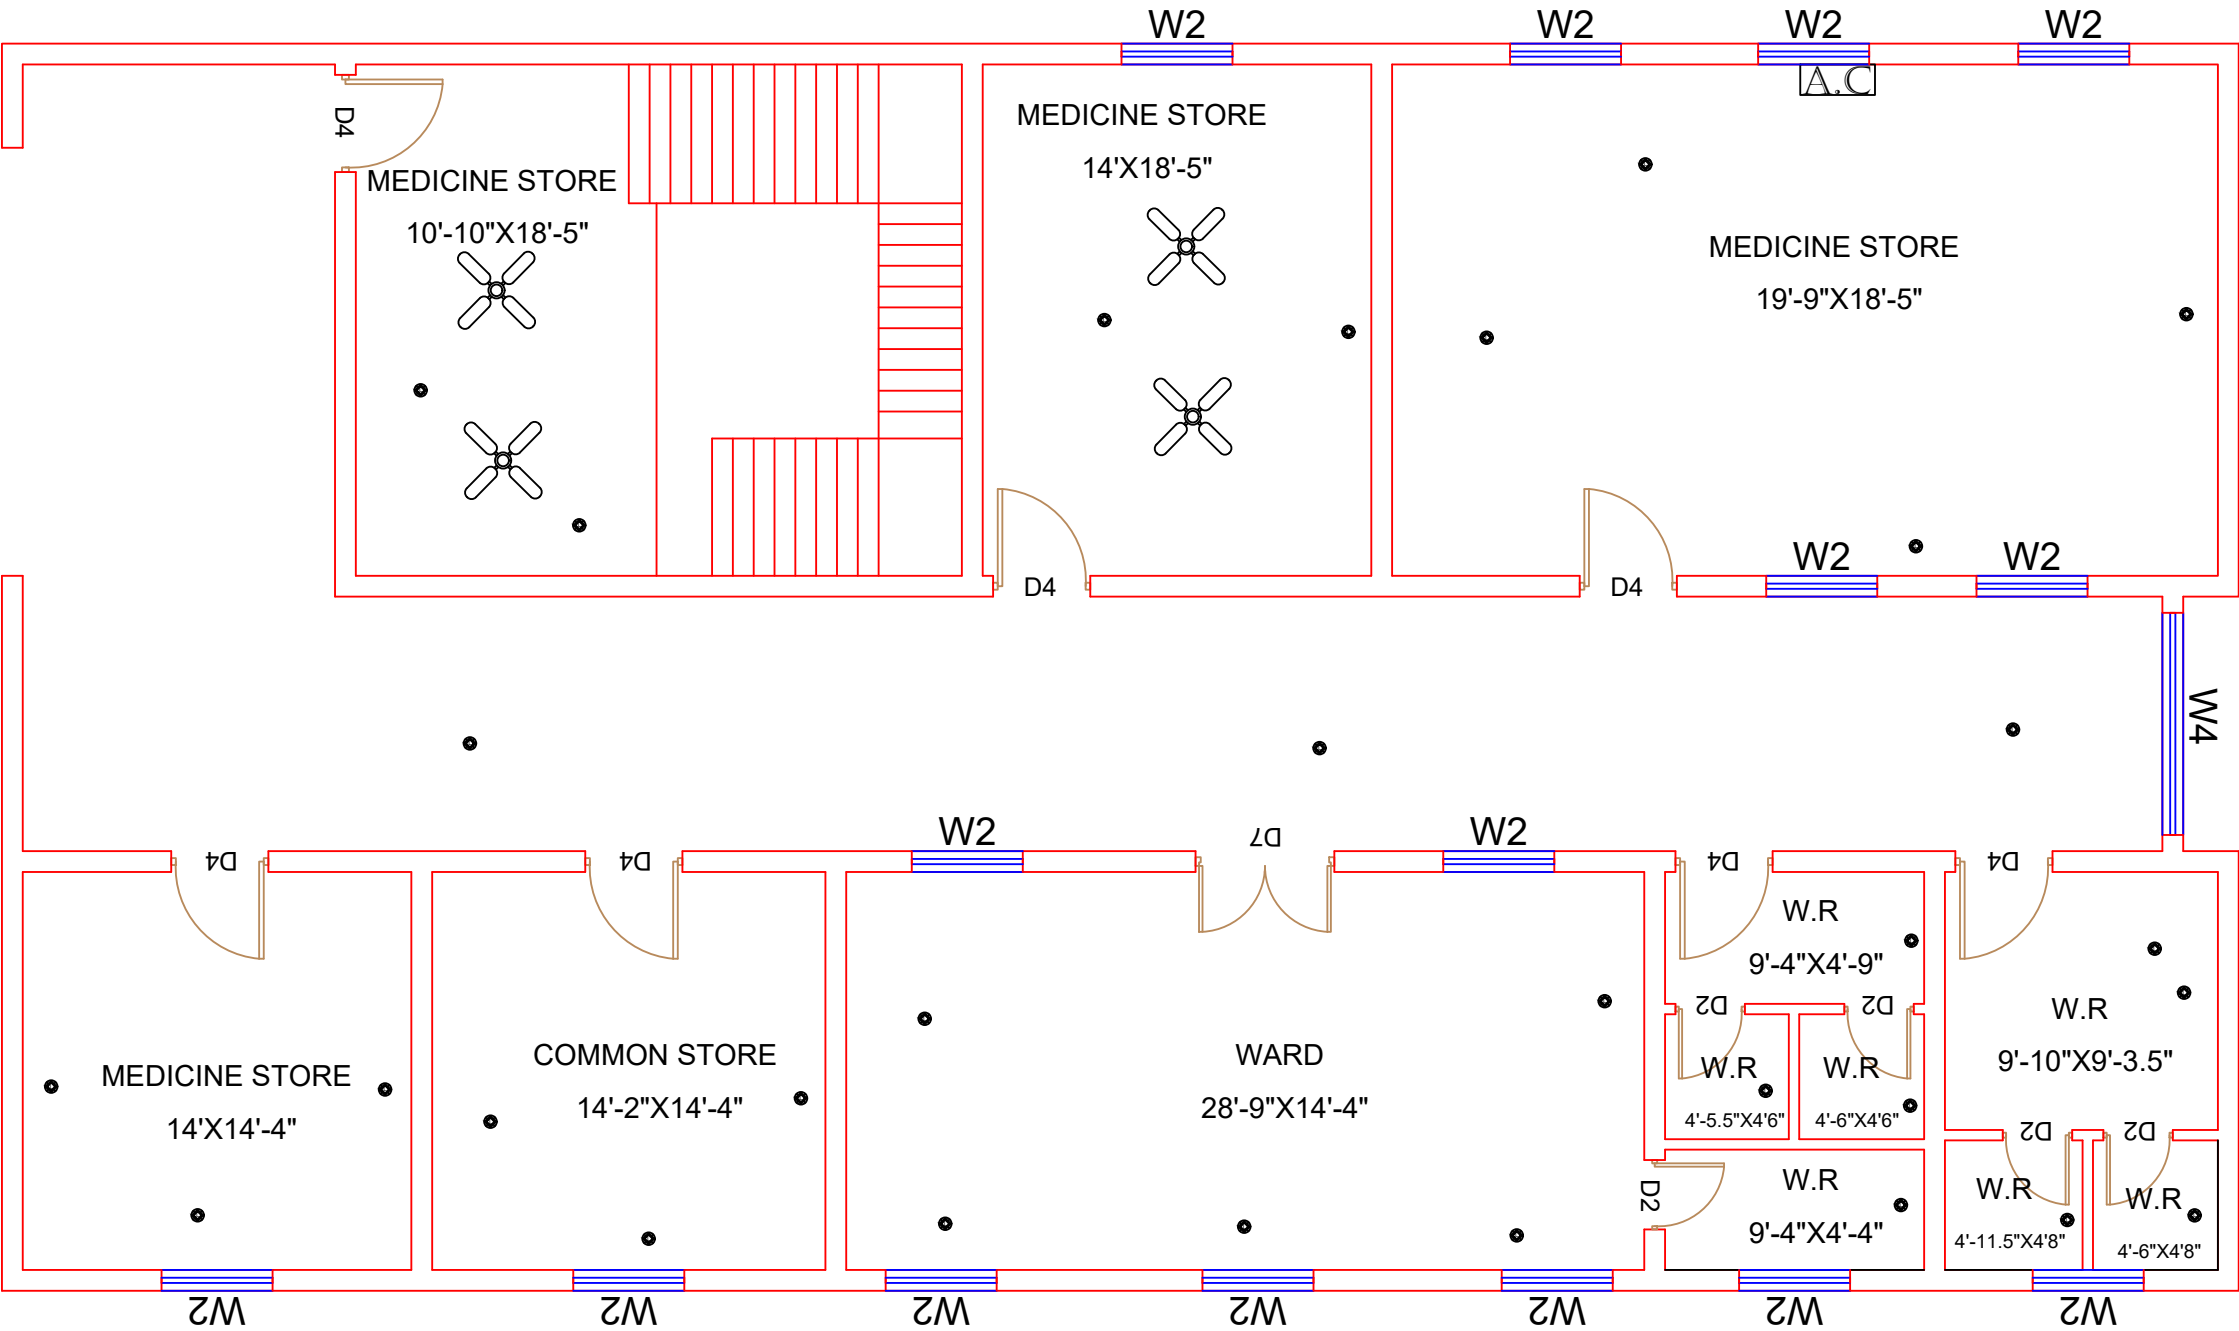

**Legends:**

|                           |  |
|---------------------------|--|
| Residential Area          |  |
| Road                      |  |
| Wall                      |  |
| Power Line                |  |
| OHT                       |  |
| Tree                      |  |
| Man Hole                  |  |
| Tube Well                 |  |
| Light Pole                |  |
| Lawns                     |  |
| Earthen Areas             |  |
| Asphalts Roads            |  |
| Tough Pavers              |  |
| P.C.C / Plinth Protection |  |
| Boundary Wall             |  |
| Brick Pavers / Soling     |  |
| Drain                     |  |
| Tap                       |  |
| Hand Pump                 |  |
| Air Conditioner           |  |
| Tube Light                |  |
| Fan                       |  |
| Roof Light                |  |
| Bulb                      |  |

| AREA                      |               |
|---------------------------|---------------|
| AREA WITHIN BOUNDARY WALL | 46104.476 Sft |
| AREA OF CLINICAL BLOCK    | 18545.614 Sft |
| PLINTH AREA OF BLOCK      | 14944.413 Sft |

| OPENING SCHEDULE OF DOORS AND WINDOWS |       |        |         |       |        |
|---------------------------------------|-------|--------|---------|-------|--------|
| DOORS                                 | WIDTH | HEIGHT | WINDOWS | WIDTH | HEIGHT |
| D1                                    | 2'-0" | 7'-0"  | W1      | 3'-0" | 5'-0"  |
| D2                                    | 2'-6" | 7'-0"  | W2      | 4'-0" | 4'-0"  |
| D3                                    | 3'-0" | 7'-0"  | W3      | 6'-0" | 6'-0"  |
| D4                                    | 3'-6" | 7'-0"  | W4      | 8'-0" | 8'-0"  |
| D5                                    | 4'-0" | 7'-0"  | W5      | 5'-0" | 5'-0"  |
| D6                                    | 4'-6" | 7'-0"  | W6      |       |        |
| D7                                    | 5'-0" | 7'-0"  | W7      |       |        |
| D8                                    | 6'-0" | 7'-0"  | V1      | 2'-0" | 2'-0"  |
| D9                                    | 7'-0" | 7'-0"  | V2      |       |        |

Project:  
**CAD MAPPING OF TEHSIL  
HEAD QUARTER HOSPITALS,  
PUNJAB**

Client:  
  
GOVERNMENT OF THE PUNJAB  
PRIMARY & SECONDARY  
HEALTHCARE DEPARTMENT

Consultant:  
  
SKAFS CONSULTANT (Pvt.)  
Limited  
ENGINEERING AND ENVIRONMENT  
CONSULTANT

Drawing Title:  
**THQ CIVIL HOSPITAL MULTAN  
ELECTRICAL PLAN (FIRST FLOOR)**

Drawing No.  
**SKAFS/CIVIL-H-MULTAN/15**